

01

02

03

04

05

06

07

08

09

10

11

12

13

14

15

16

17

18

19

20

21

22

23

24

25

26

27

28

29

30

31

32

33

34

35

36

37

38

39

40

41

A

B

C

D

E

F

G

H

J

K

L

M

N

P

Q

R

CUSTOMER: CARRIER CORPORATION

CUSTOMER ORDER NUMBER:

DISTRIBUTOR:

DISTRIBUTOR ORDER NUMBER:

PROJECT:

PROJECT ORDER NUMBER:

ROCKWELL AUTOMATION ORDER NUMBER: CARRIER

NOTE: SPECIFIC DRAWINGS WILL BE SUPPLIED
TO EACH PARTICULAR ORDER.

SERIES NUMBER	UNIT NUMBER	EQUIPMENT DESCRIPTION	PAGE DESCRIPTION	SHEET
			PROJECT TITLE AND DRAWING INDEX	1
			GENERAL NOTES AND DEVICE DESIGNATIONS	2
			ONE LINE DIAGRAM AND KEY INTERLOCKING	3
			POWER WIRING INTERCONNECTIONS	4
			CONTROL WIRING INTERCONNECTIONS AND TERMINAL BLOCK LAYOUTS	5-6
XXXXXX-XXX-13E	1A-2A	MEDIUM VOLTAGE AC DRIVE	LINE AND LOAD CONNECTIONS	7
			RECTIFIER, INVERTER AND COMMON MODE CHOKE	8
			MAIN COOLING FAN	9
			CONTROL POWER DISTRIBUTION	10
			GATE DRIVER POWER SUPPLIES	11
			OPTICAL INTERFACE BOARDS	12
			ANALOG CONTROL BOARD	13-14
			EXTERNAL I/O BOARD	15
			SYMBOL TABLE	16

THIS DRAWING IS THE PROPERTY OF
ROCKWELL AUTOMATION, INC. OR ITS
SUBSIDIARIES AND MAY NOT BE COPIED,
USED OR DISCLOSED FOR ANY PURPOSE
EXCEPT AS AUTHORIZED IN WRITING BY
ROCKWELL AUTOMATION, INC.

CERTIFIED
M.VARGAS

DRAWN
J.FILIPOVIC

DATE
2013-06-28

REV
1

REVISION
PRELIMINARY

INT
JF

DATE
2013-06-28

CUSTOMER
CARRIER CORPORATION

DISTRIBUTOR

PROJECT

ORDER NO.

DESCRIPTION
DRAWING INDEX

BULLETIN
7000A

SIZE
XXXA

Rockwell
Automation

REV
1

DWG. NO.
CARRIER-003-13E

SHEET
1

OF
16

AB

Allen-Bradley

E-DH-C

A

B

C

D

E

F

G

H

J

K

L

M

N

P

Q

R

AutoCAD®

KEY INTERLOCK SYSTEM SUPPLIED BY ROCKWELL AUTOMATION

DANGER

SYSTEM INTEGRITY DEPENDS ON HAVING ONLY ONE KEY FOR EACH INTERCHANGE DESIGNATION. IF MORE KEYS ARE AVAILABLE THE INTERLOCKING INTEGRITY IS LOST. SAFETY OF PERSONNEL AND EQUIPMENT WILL BE AFFECTED.

THE CUSTOMER MUST ENSURE THAT HIS CONFIGURATION OF THIS EQUIPMENT INTO HIS SYSTEM DOES NOT RESULT IN DAMAGE TO THIS EQUIPMENT. THE SYSTEM SHOWN HERE IS DESIGNED TO ACHIEVE THE FUNCTION DESCRIBED BELOW.

DANGER

OBSERVE CAPACITOR DANGER LABELS ON DOORS. EXTERNAL CONTROL VOLTAGES WILL BE PRESENT. SEE DIAGRAMS.

FUNCTION

THE KEY INTERLOCK SYSTEM PREVENTS ACCESS TO THE MEDIUM VOLTAGE SECTIONS OF THE POWERFLEX 7000 DRIVE UNTIL THE MEDIUM VOLTAGE SUPPLY IS LOCKED OFF AT THE DRIVE INPUT CONTACTOR UNIT.

TO GAIN ACCESS TO THE DRIVE MEDIUM VOLTAGE SECTIONS

- 1) IF THE DRIVE IS RUNNING THE MOTOR, FIRST STOP THE MOTOR.
- 2) OPEN THE INPUT CONTACTOR BY PRESSING DRIVE EMERGENCY STOP.
- 3) OPEN THE INPUT ISOLATING SWITCH. LOCK IT OPEN AND REMOVE KEY K1.
- 4) INSERT KEY K1 INTO THE KEY DOOR LOCK IN THE DRIVE INVERTER/RECTIFIER SECTION. THIS DOOR CAN NOW BE UNLOCKED.
- 5) TO RESTORE EQUIPMENT TO ORIGINAL SERVICE POSITION, REVERSE THE ABOVE STEPS.

CABLE INSULATION REQUIREMENTS FOR "DIRECT TO DRIVE" TECHNOLOGY

SYSTEM VOLTAGE	CABLE INSULATION RATING (kV)	
	LINE SIDE	MACHINE SIDE
2400	> 2.2	> 2.2
3000	> 2.75	> 2.75
3300	> 3.0	> 3.0
4160	> 3.8	> 3.8
6000	> 5.5	> 5.5
6300	> 5.8	> 5.8
6600	> 6.0	> 6.0

LEGEND

L-O LOCKED OPEN

L-C LOCKED CLOSED


(K) KEY INTERLOCK ON ISOLATION SWITCH

[K] KEY INTERLOCK ON MV DOOR


(K)(K) MULTIPLE BARREL KEY INTERLOCK ON ISOLATION SWITCH


[K][K] MULTIPLE BARREL KEY INTERLOCK ON MV DOOR

[K][K][K][K] TRANSFER BLOCK

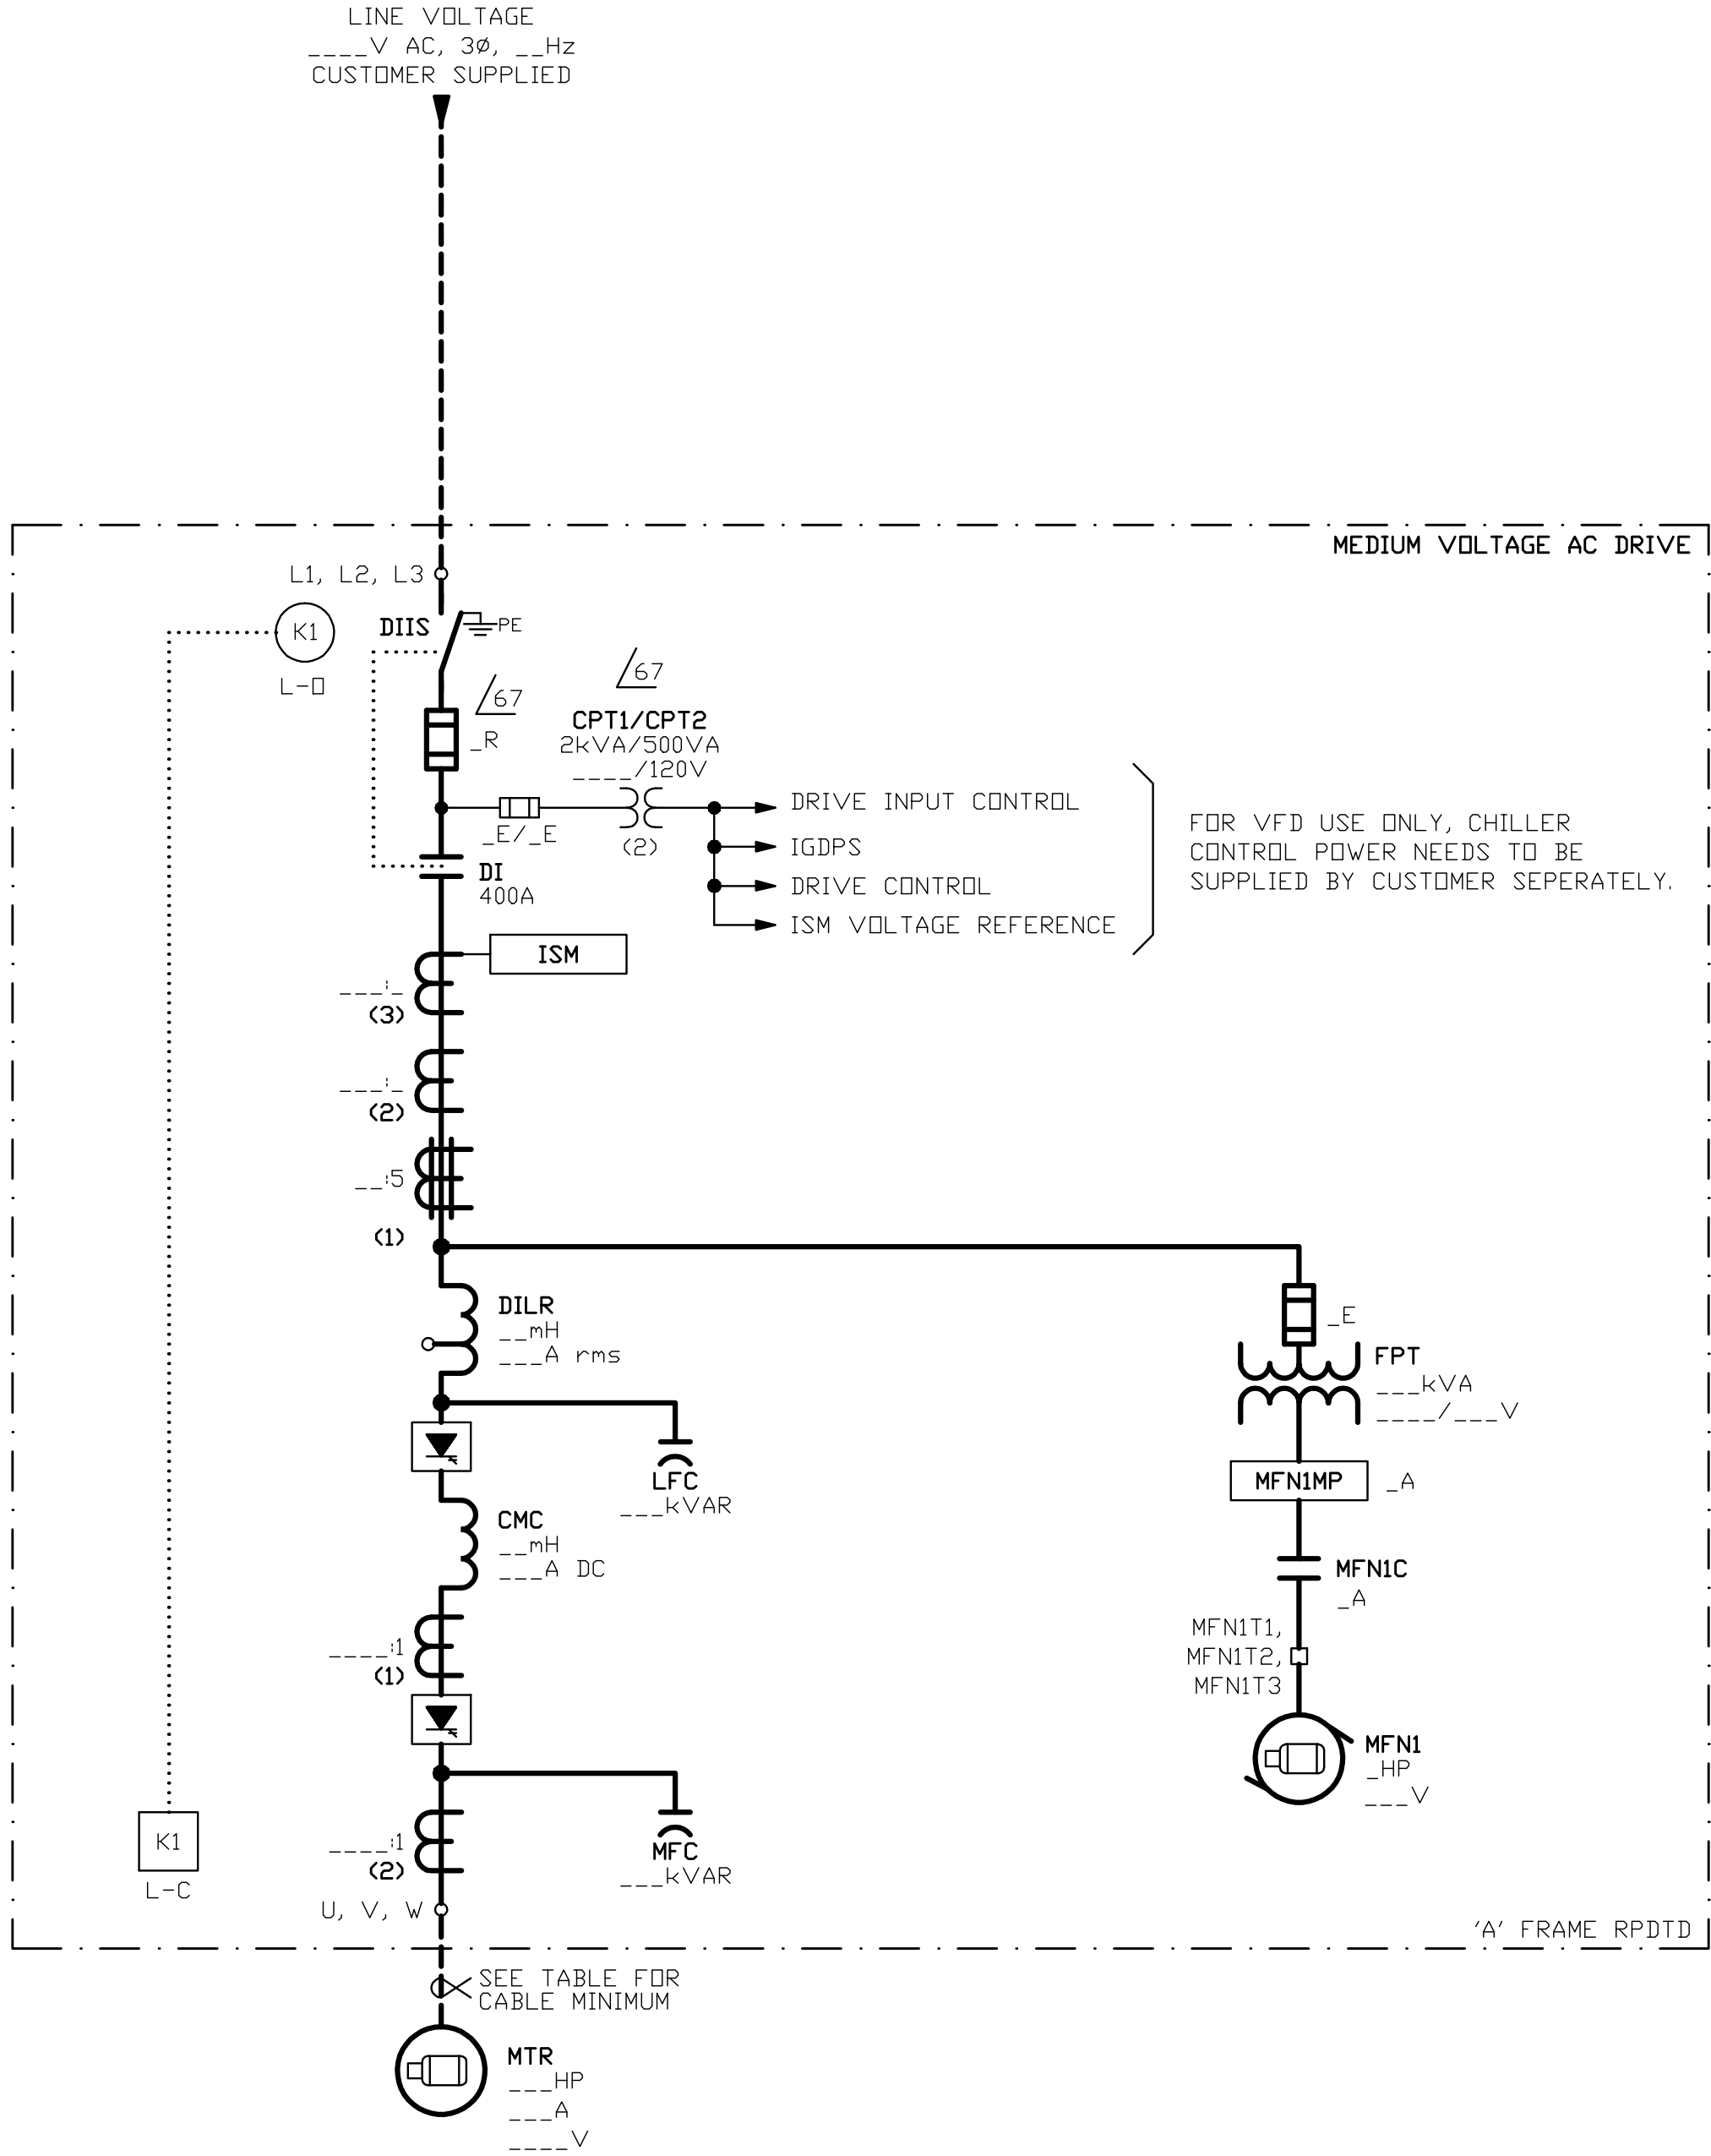









THIS DRAWING IS THE PROPERTY OF ROCKWELL AUTOMATION, INC. OR ITS SUBSIDIARIES AND MAY NOT BE COPIED, USED OR DISCLOSED FOR ANY PURPOSE EXCEPT AS AUTHORIZED IN WRITING BY ROCKWELL AUTOMATION, INC.	CERTIFIED	DATE	REV	REVISION		INT	DATE	CUSTOMER		ORDER NO.		DESCRIPTION ONE LINE DIAGRAM	BULLETIN		7000A	SIZE	XXXA	REV	DWG. NO.		SHEET	3
	M.VARGAS		1	PRELIMINARY		JF	2013-06-28	CARRIER CORPORATION					Allen-Bradley									
	DRAWN	DATE						DISTRIBUTOR														
	J.FILIPOVIC	2013-06-28						PROJECT														

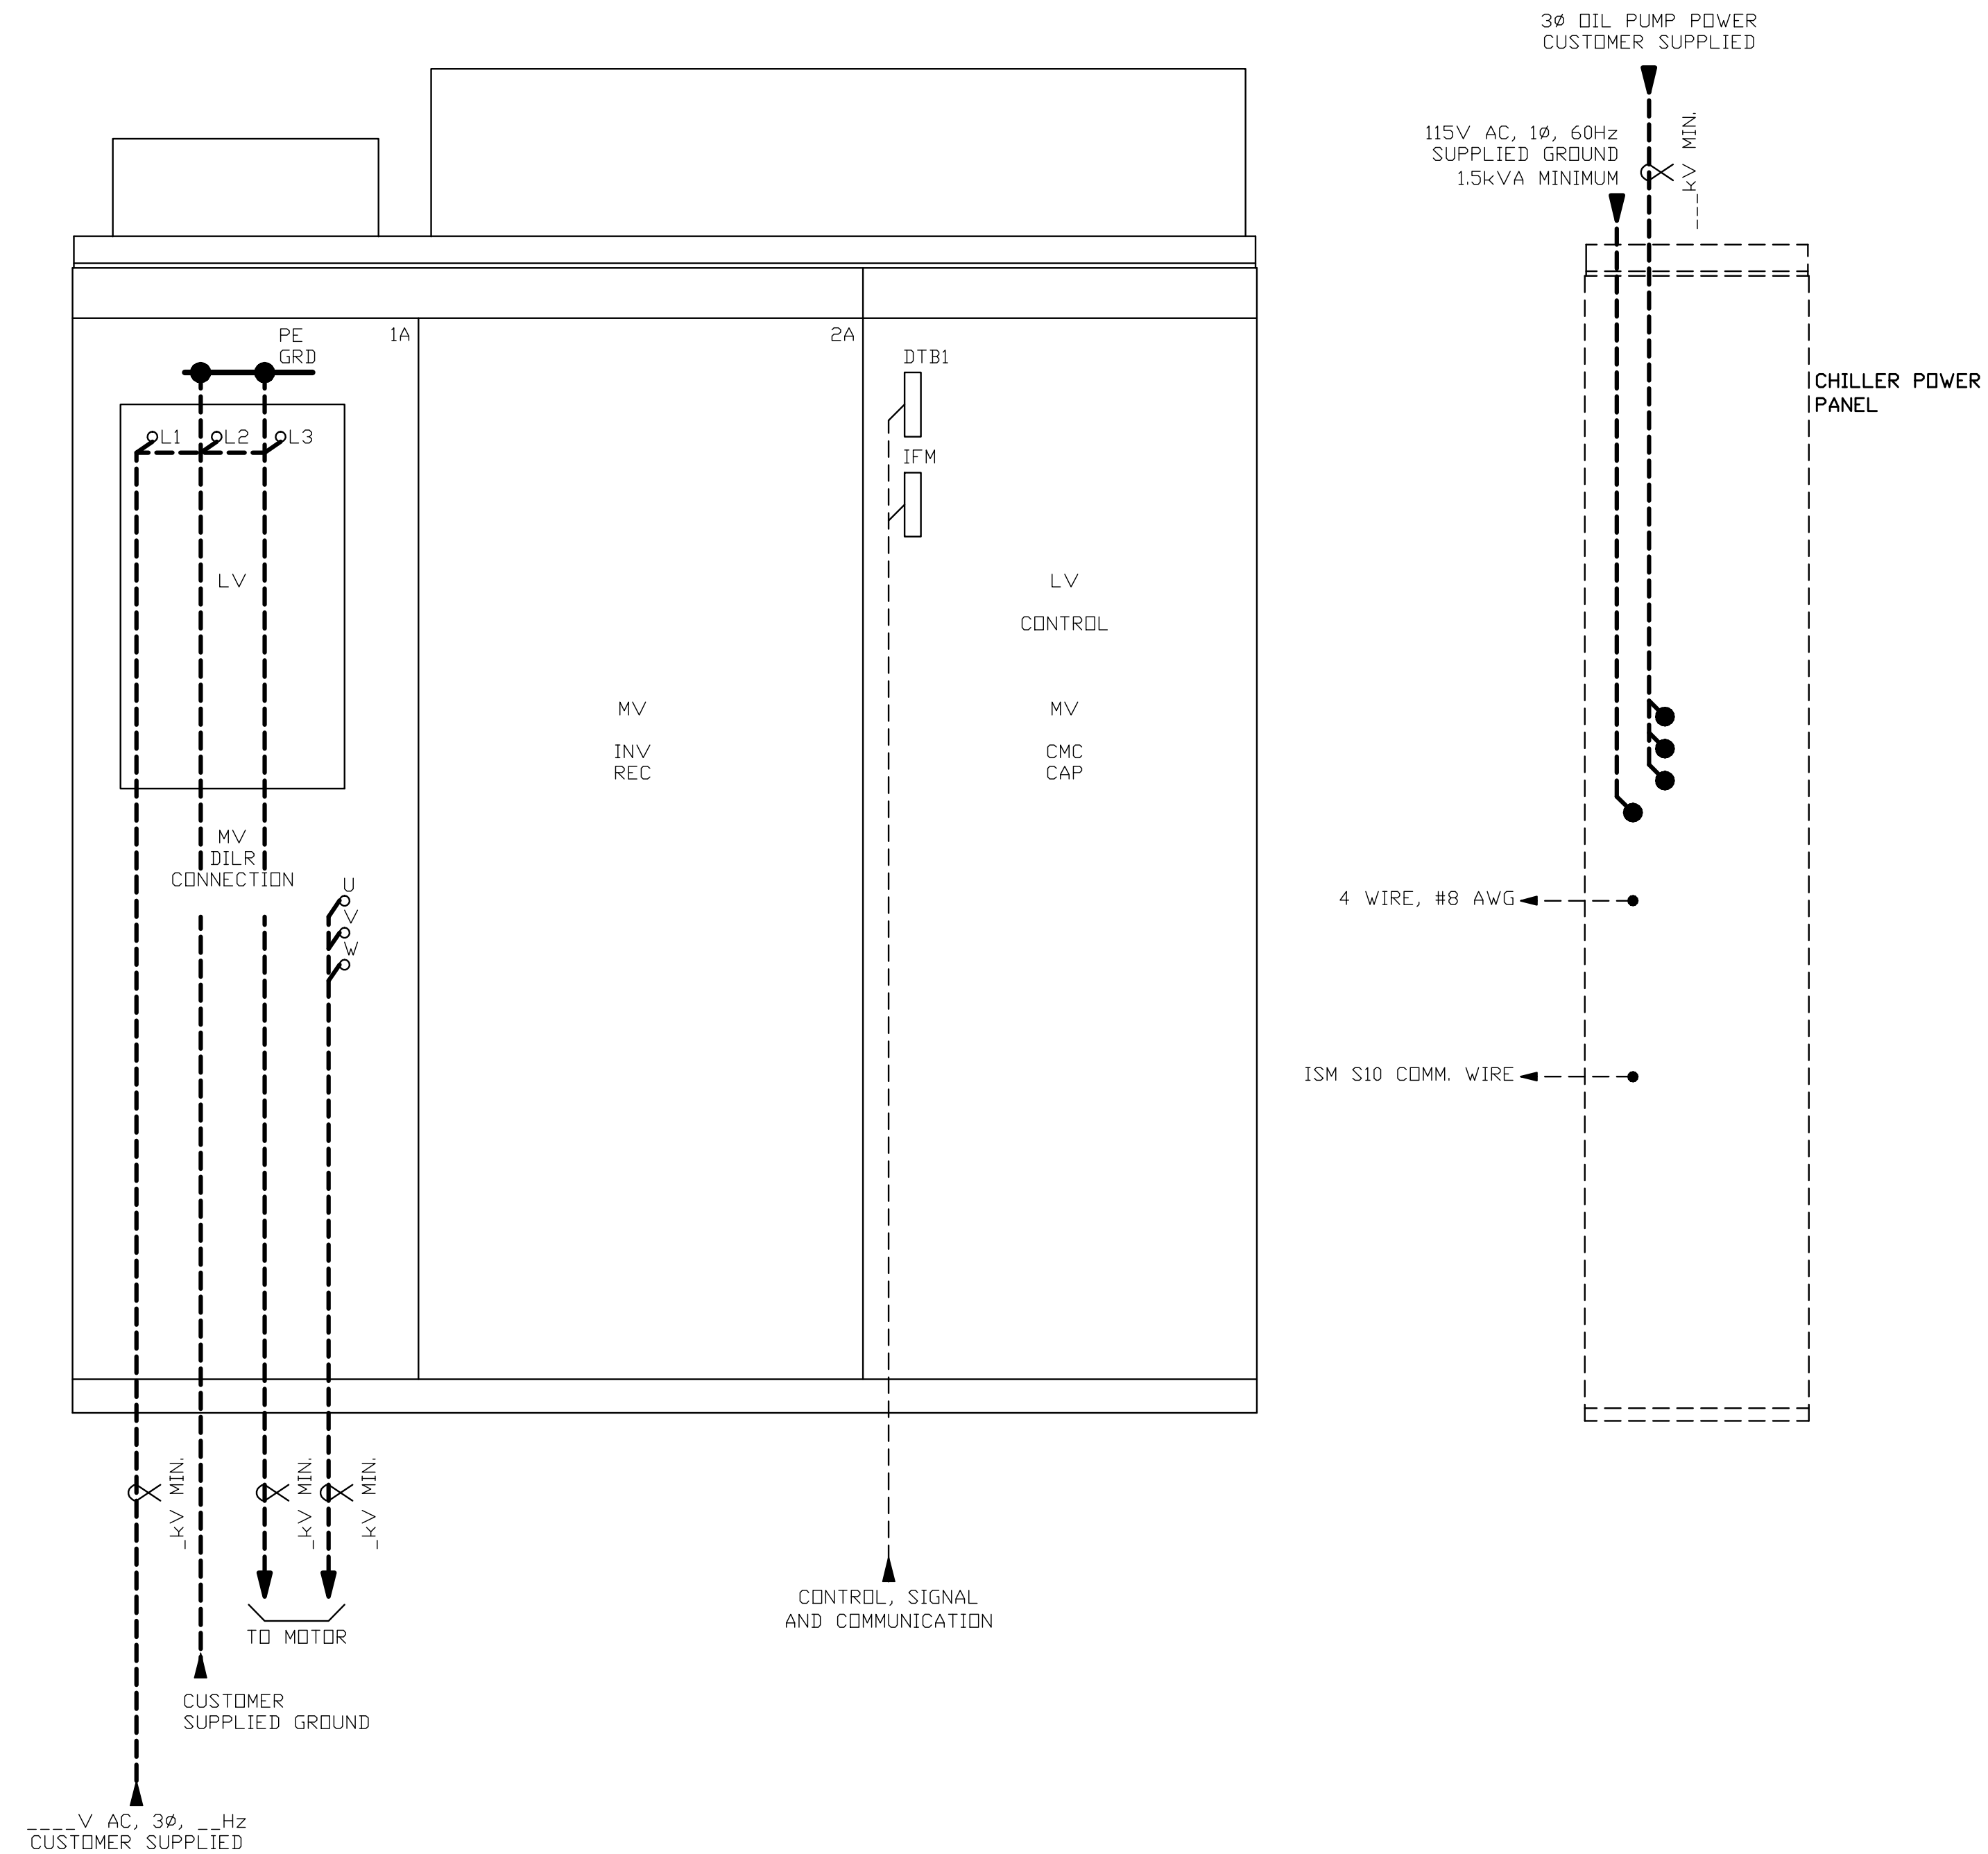E-DH-C

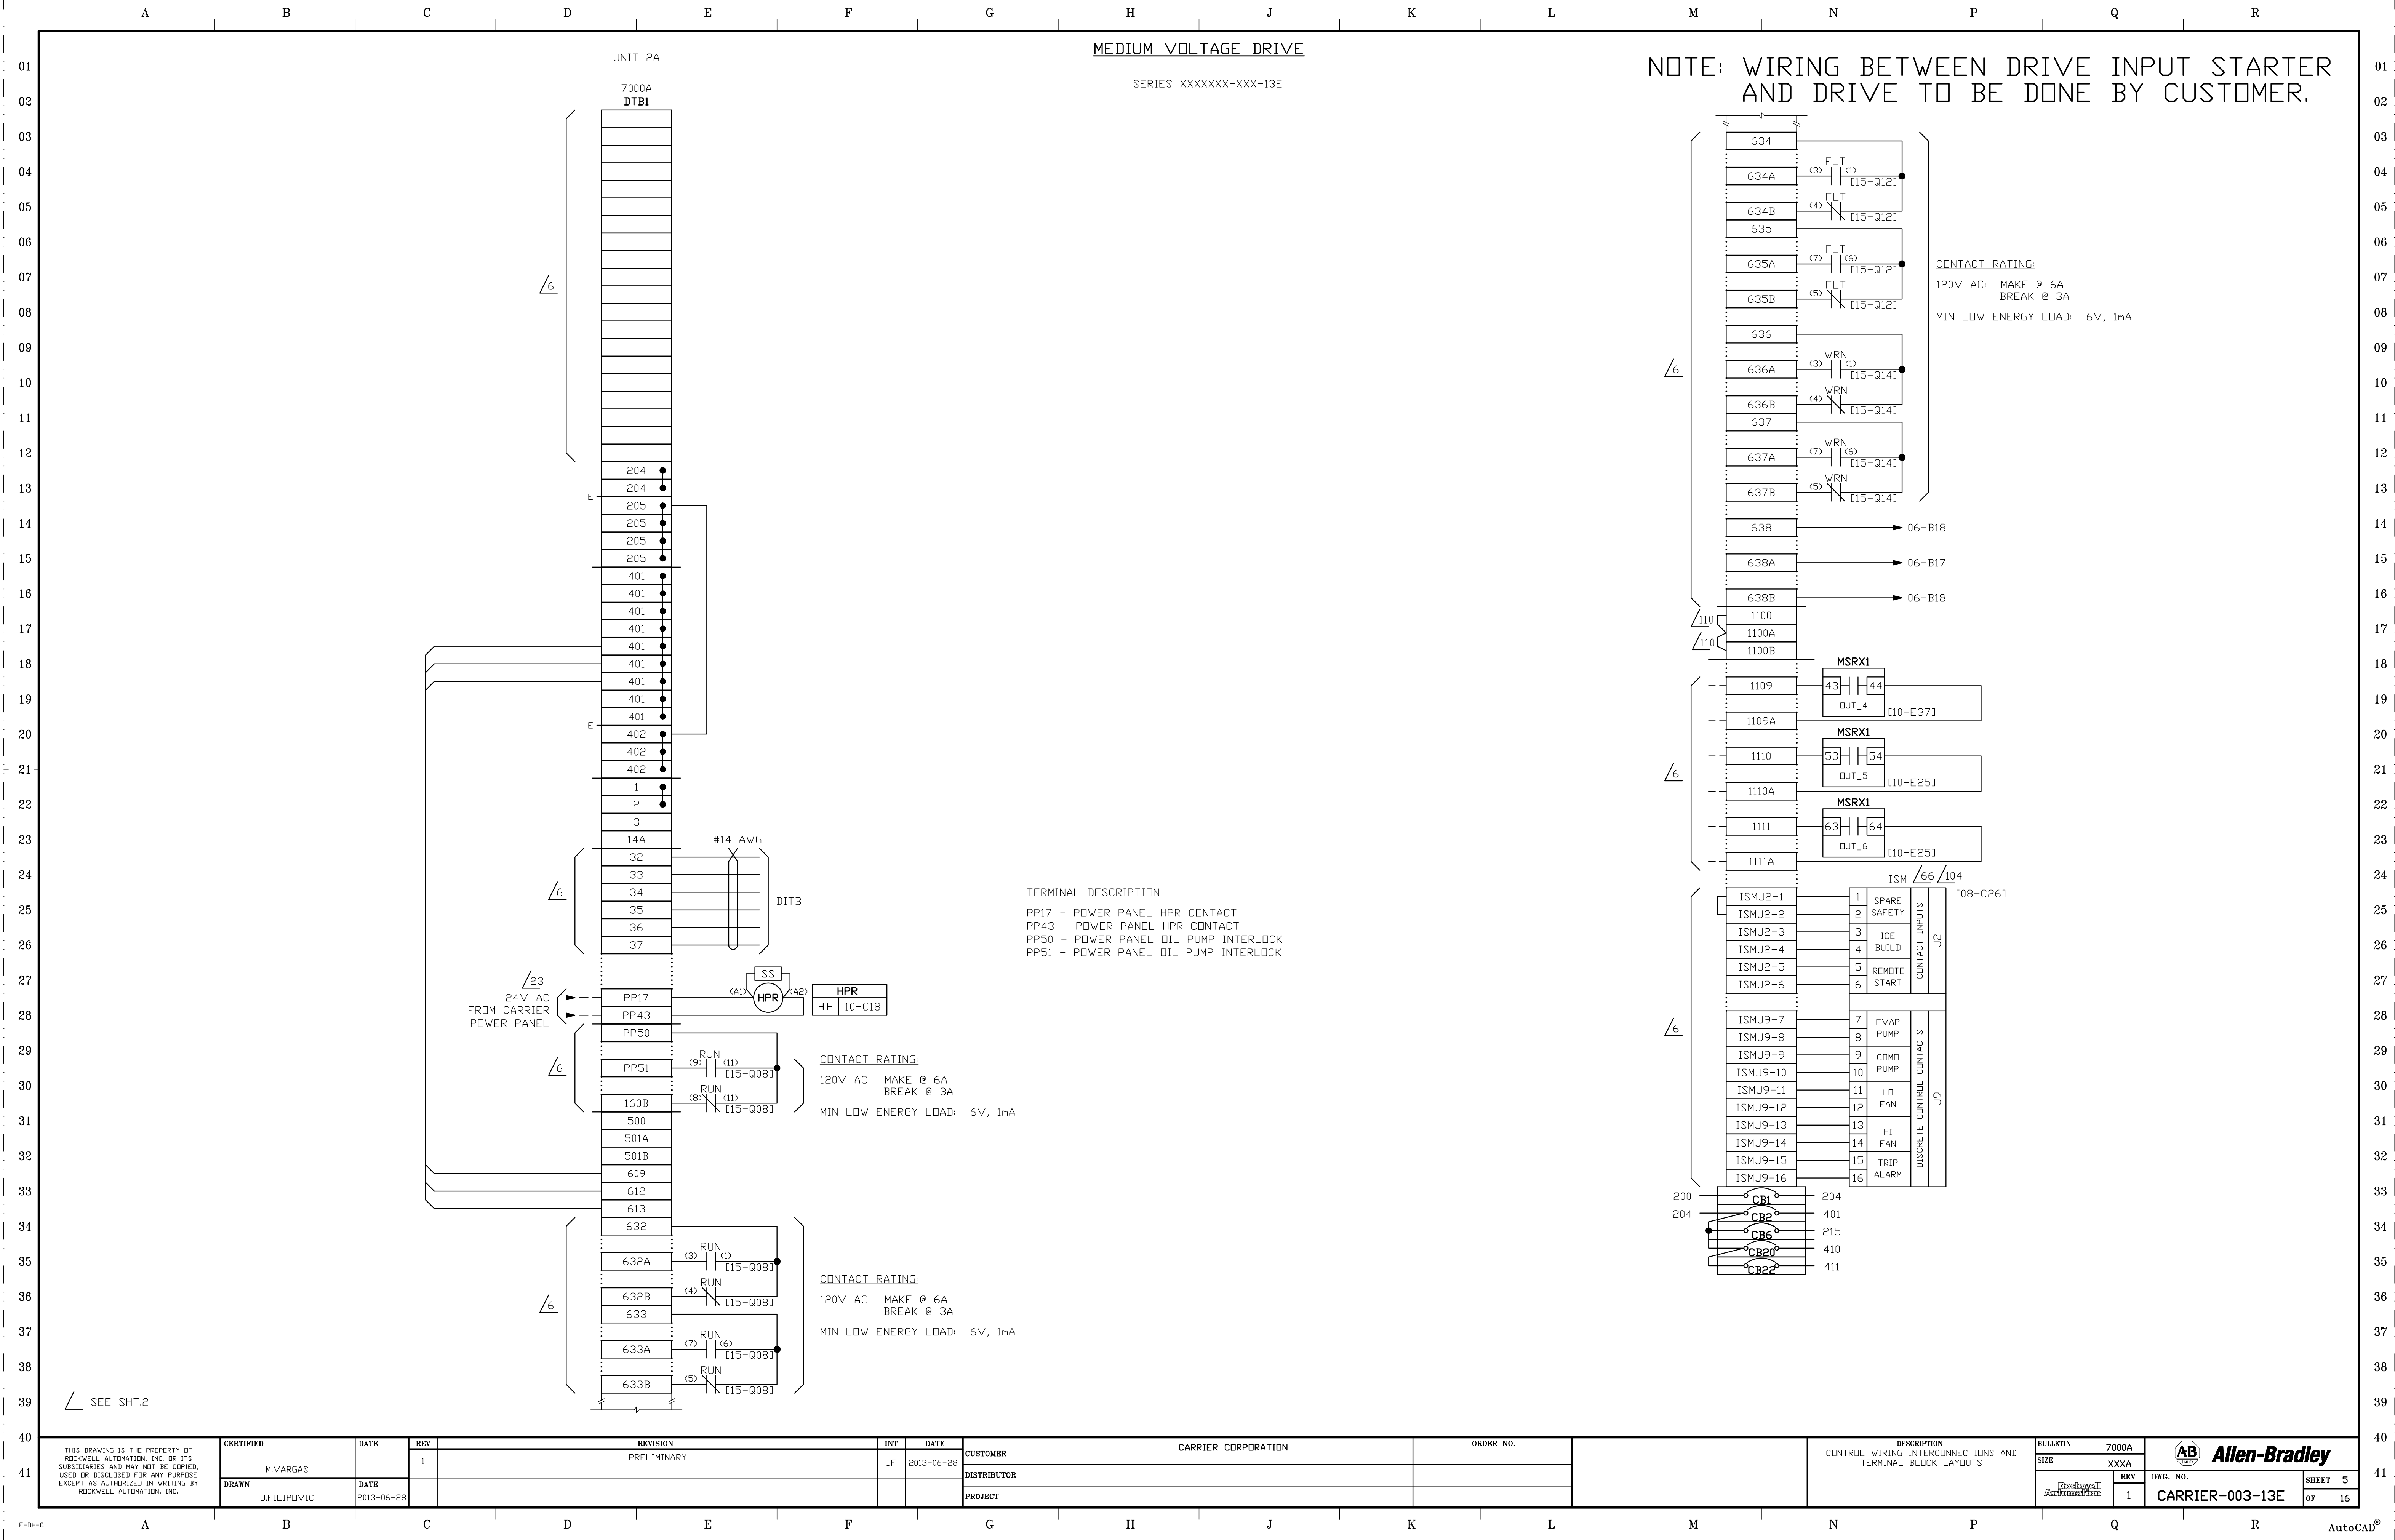


MEDIUM VOLTAGE DRIVE

ROCKWELL AUTOMATION USE TERMINAL BLOCKS

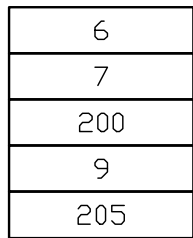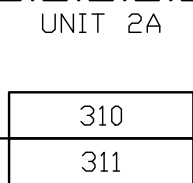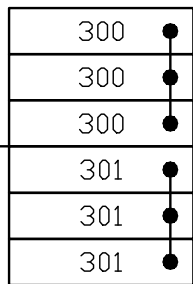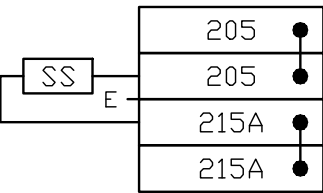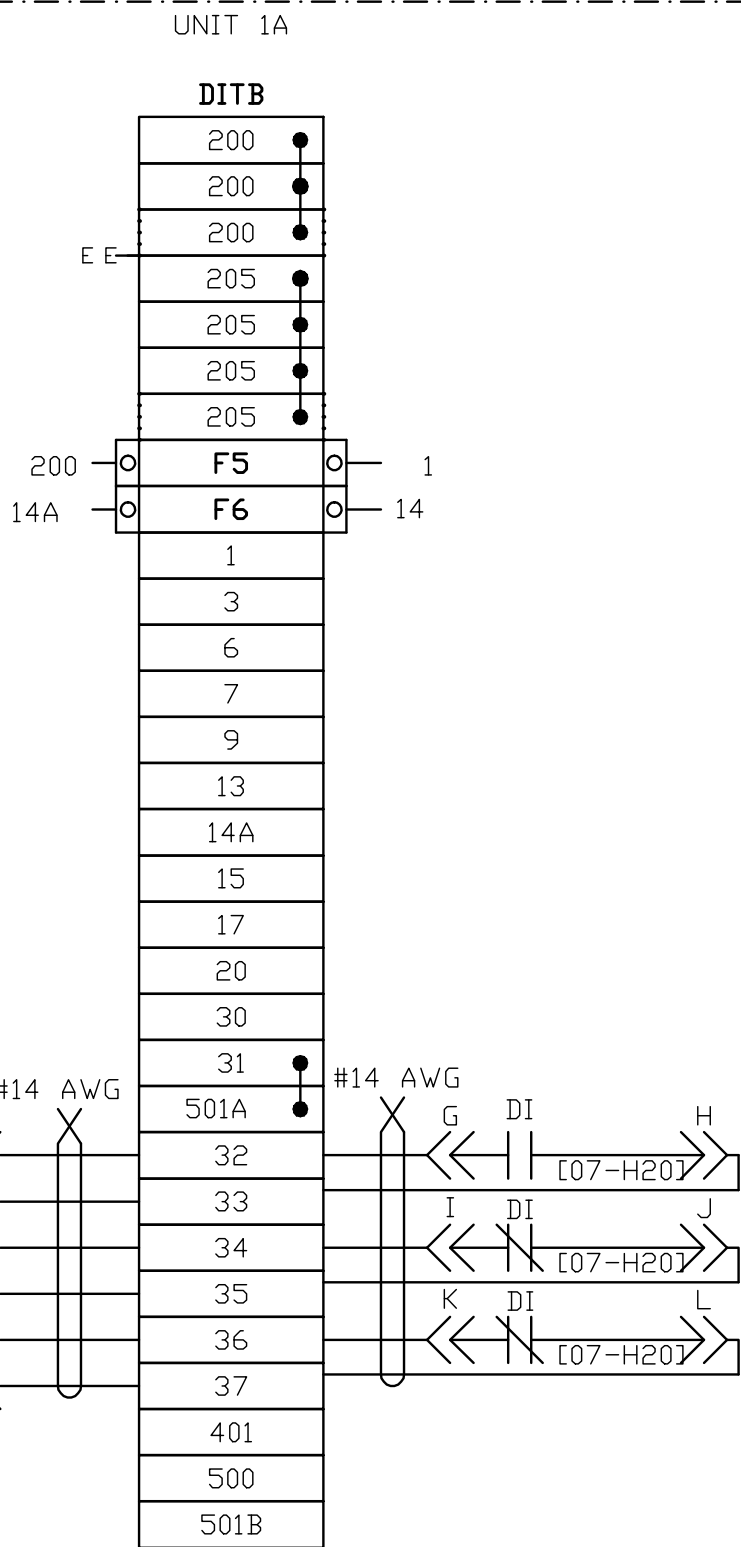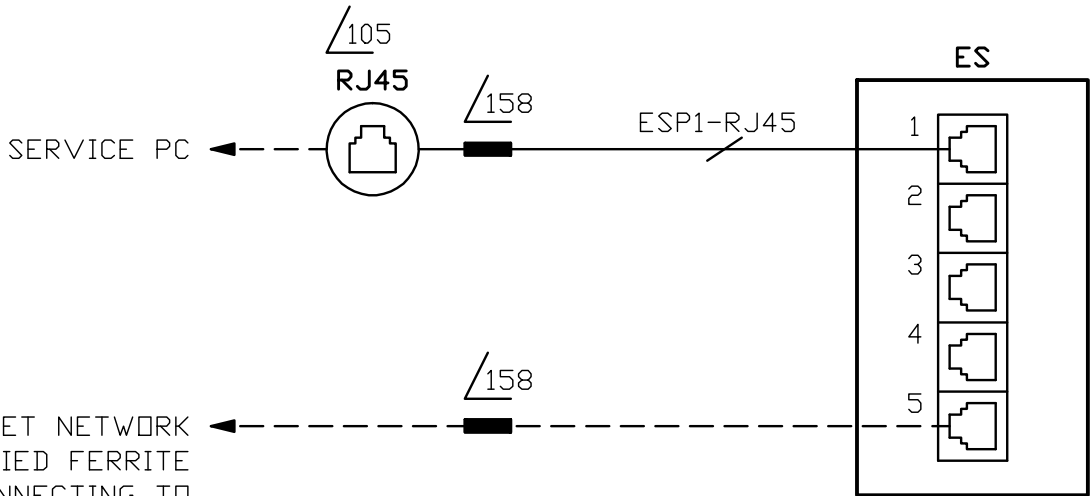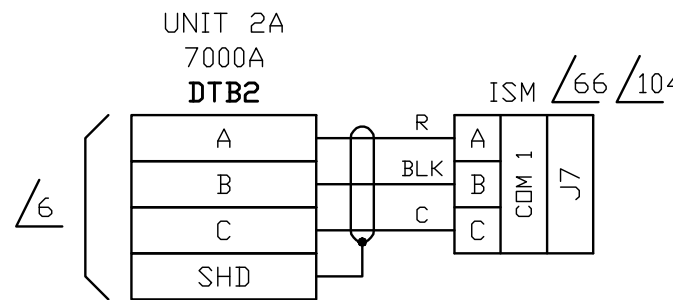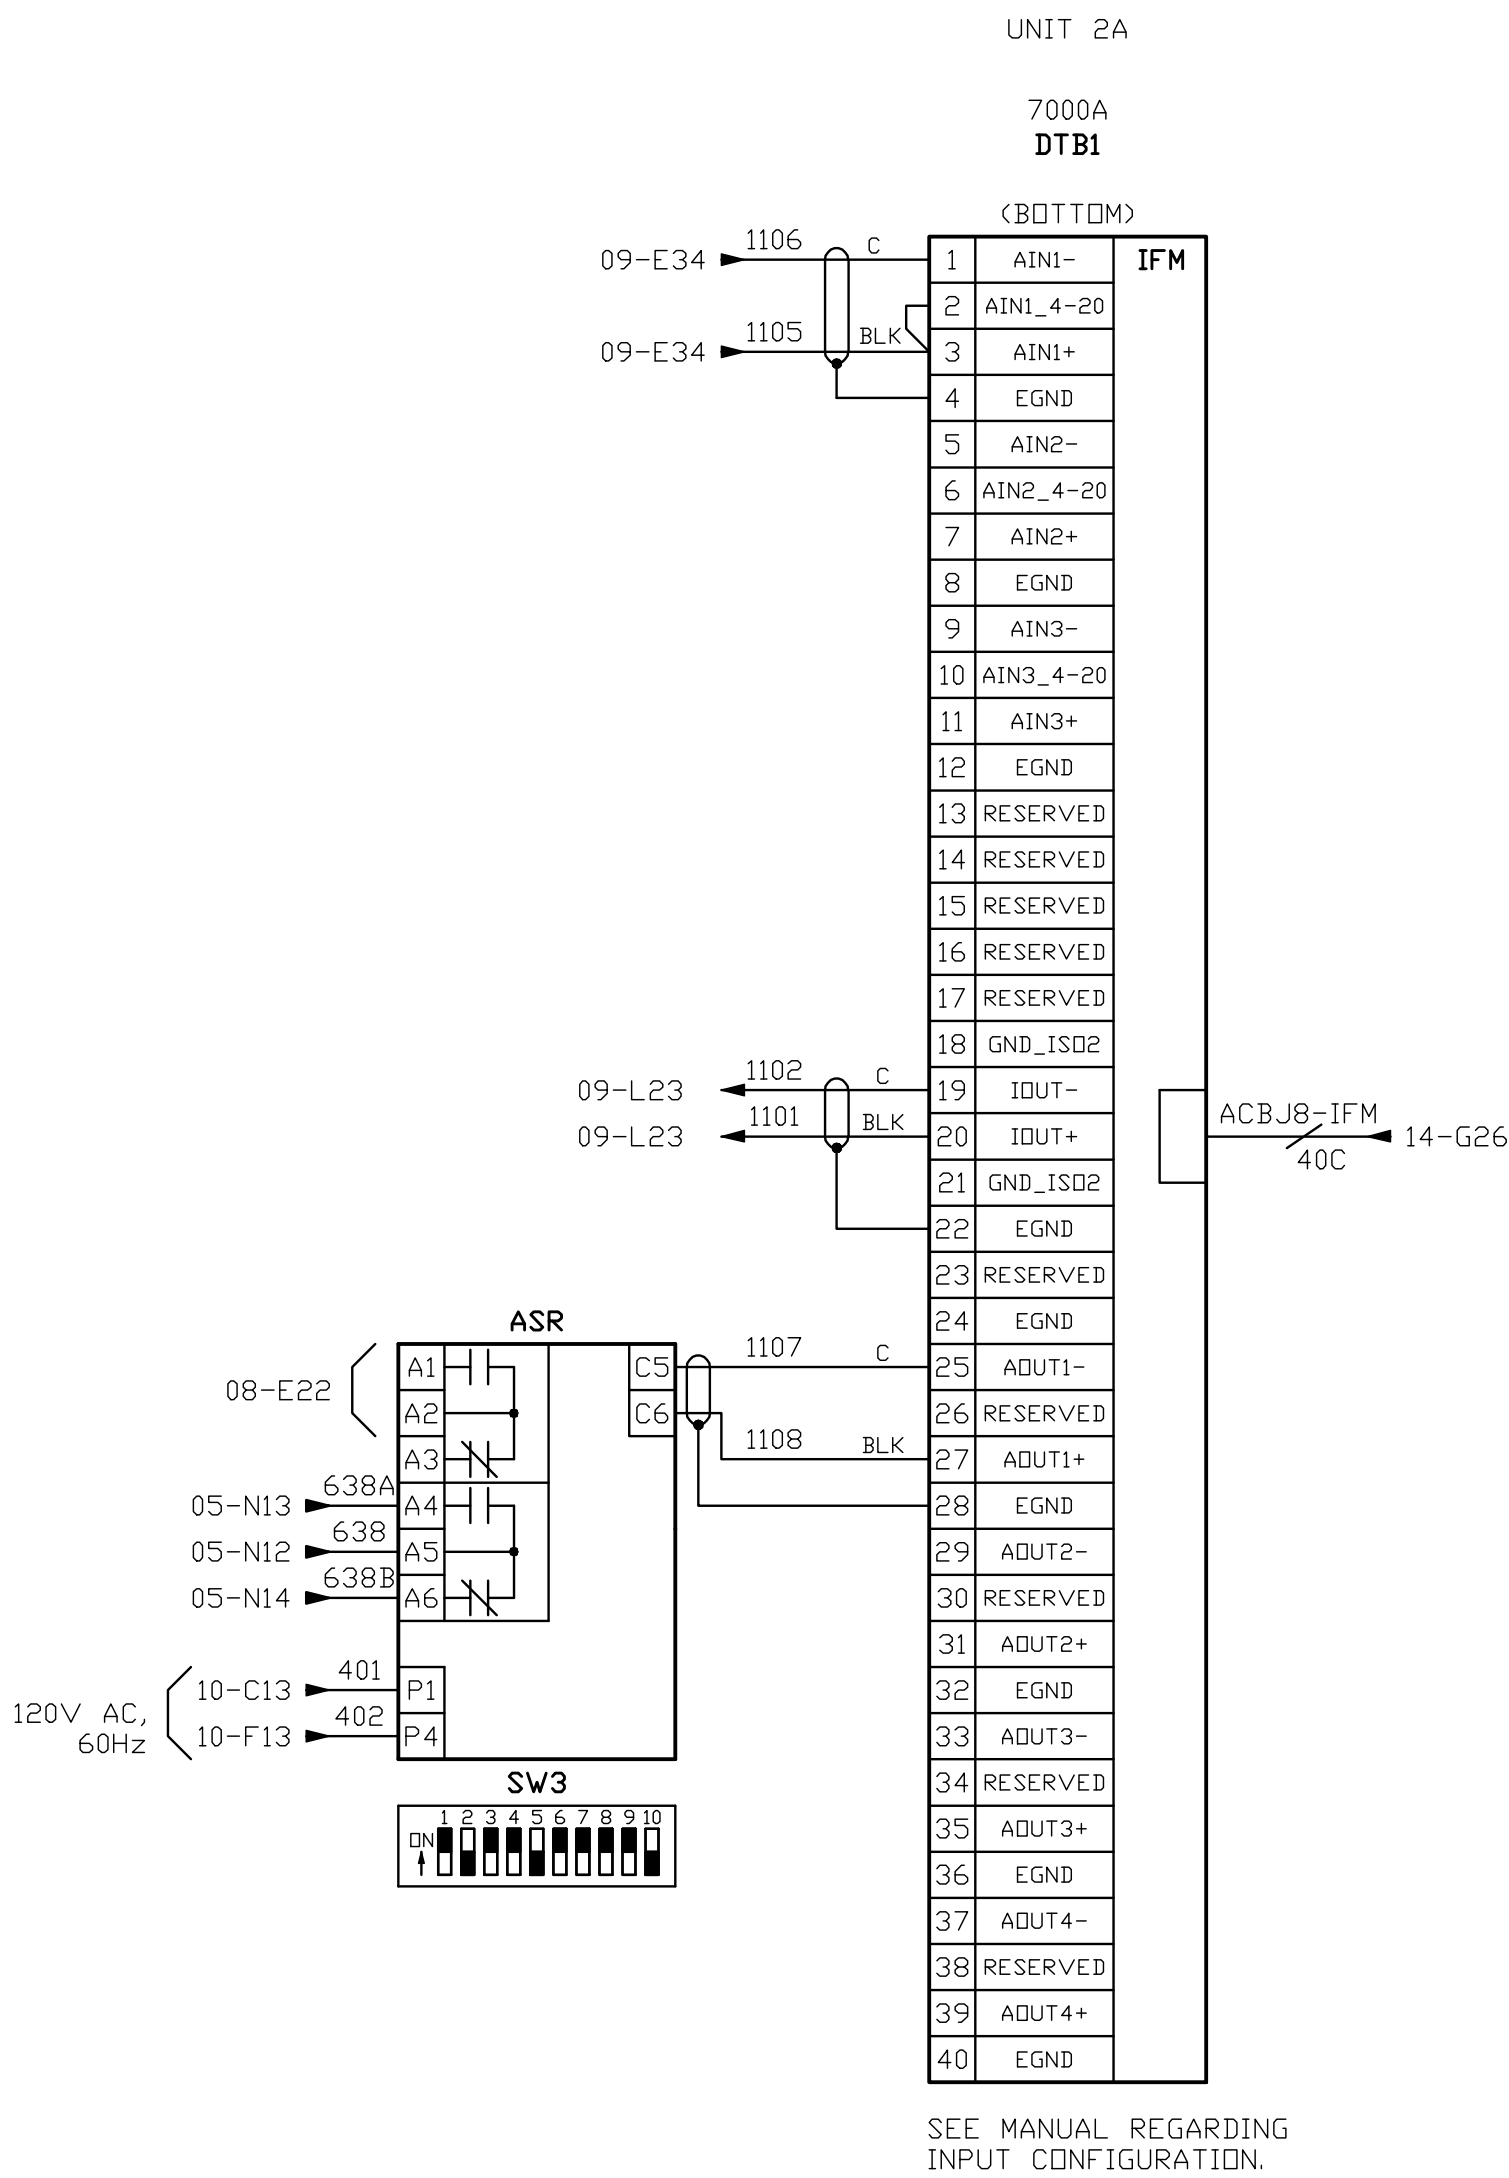

SEE SHT.2


THIS DRAWING IS THE PROPERTY OF ROCKWELL AUTOMATION, INC. OR ITS SUBSIDIARIES AND MAY NOT BE COPIED, USED OR DISCLOSED FOR ANY PURPOSE EXCEPT AS AUTHORIZED IN WRITING BY ROCKWELL AUTOMATION, INC.	CERTIFIED	DATE	REV	REVISION		INT	DATE	CUSTOMER		CARRIER CORPORATION		ORDER NO.		DESCRIPTION CONTROL WIRING INTERCONNECTIONS AND TERMINAL BLOCK LAYOUTS	BULLETIN		7000A			Allen-Bradley					
	M.VARGAS		1	PRELIMINARY		JF	2013-06-28	DISTRIBUTOR							SIZE		XXXA								
	DRAWN	DATE						PROJECT									REV					DWG. NO.		SHEET	
	J.FILIPOVIC	2013-06-28													1		CARRIER-003-13E					6			
																				OF		16			

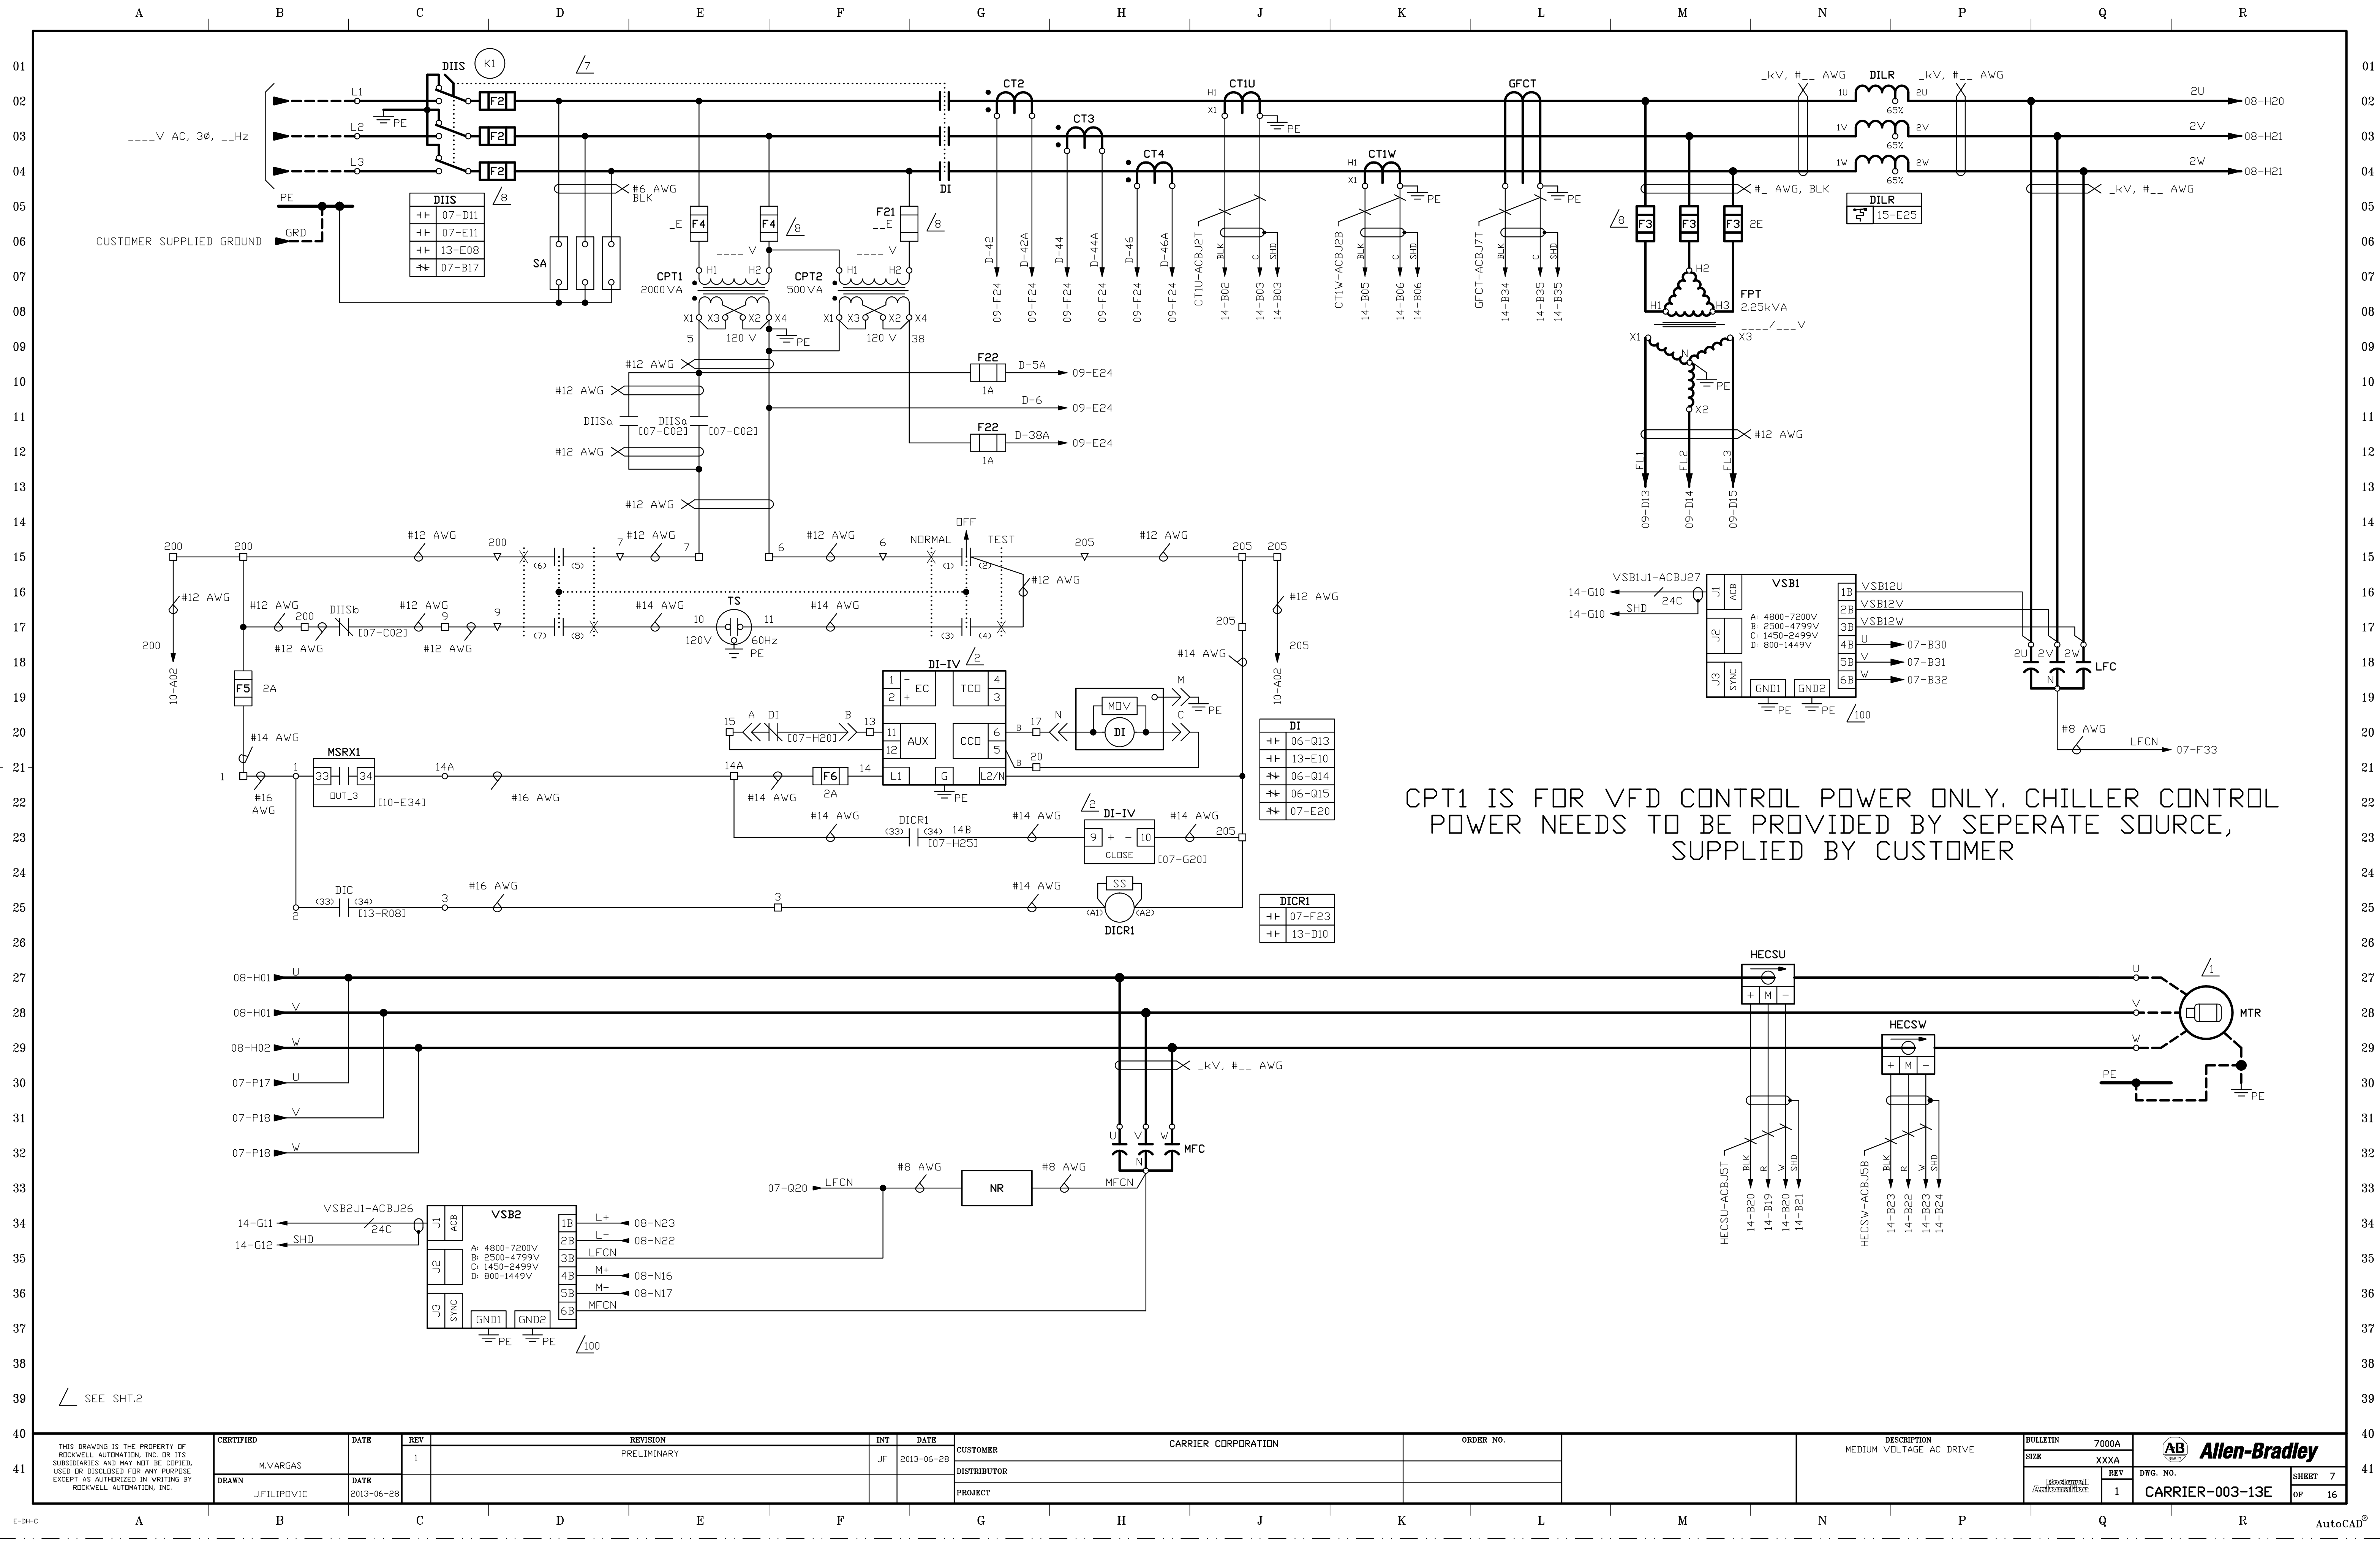

CPT1 IS FOR VFD CONTROL POWER ONLY. CHILLER CONTROL POWER NEEDS TO BE PROVIDED BY SEPERATE SOURCE, SUPPLIED BY CUSTOMER

SEE SHT.2



THIS DRAWING IS THE PROPERTY OF ROCKWELL AUTOMATION, INC. OR ITS SUBSIDIARIES AND MAY NOT BE COPIED, USED OR DISCLOSED FOR ANY PURPOSE EXCEPT AS AUTHORIZED IN WRITING BY ROCKWELL AUTOMATION, INC.	CERTIFIED	DATE	REV	REVISION	INT	DATE	CUSTOMER	ORDER NO.	DESCRIPTION MEDIUM VOLTAGE AC DRIVE	BULLETIN 7000A	SIZE XXXXA	REV 1	DWG. NO. CARRIER-003-13E	SHEET 7
	M.VARGAS		1	PRELIMINARY	JF	2013-06-28	CARRIER CORPORATION							
	DRAWN	DATE					DISTRIBUTOR							
	J.FILIPPOVIC	2013-06-28					PROJECT							

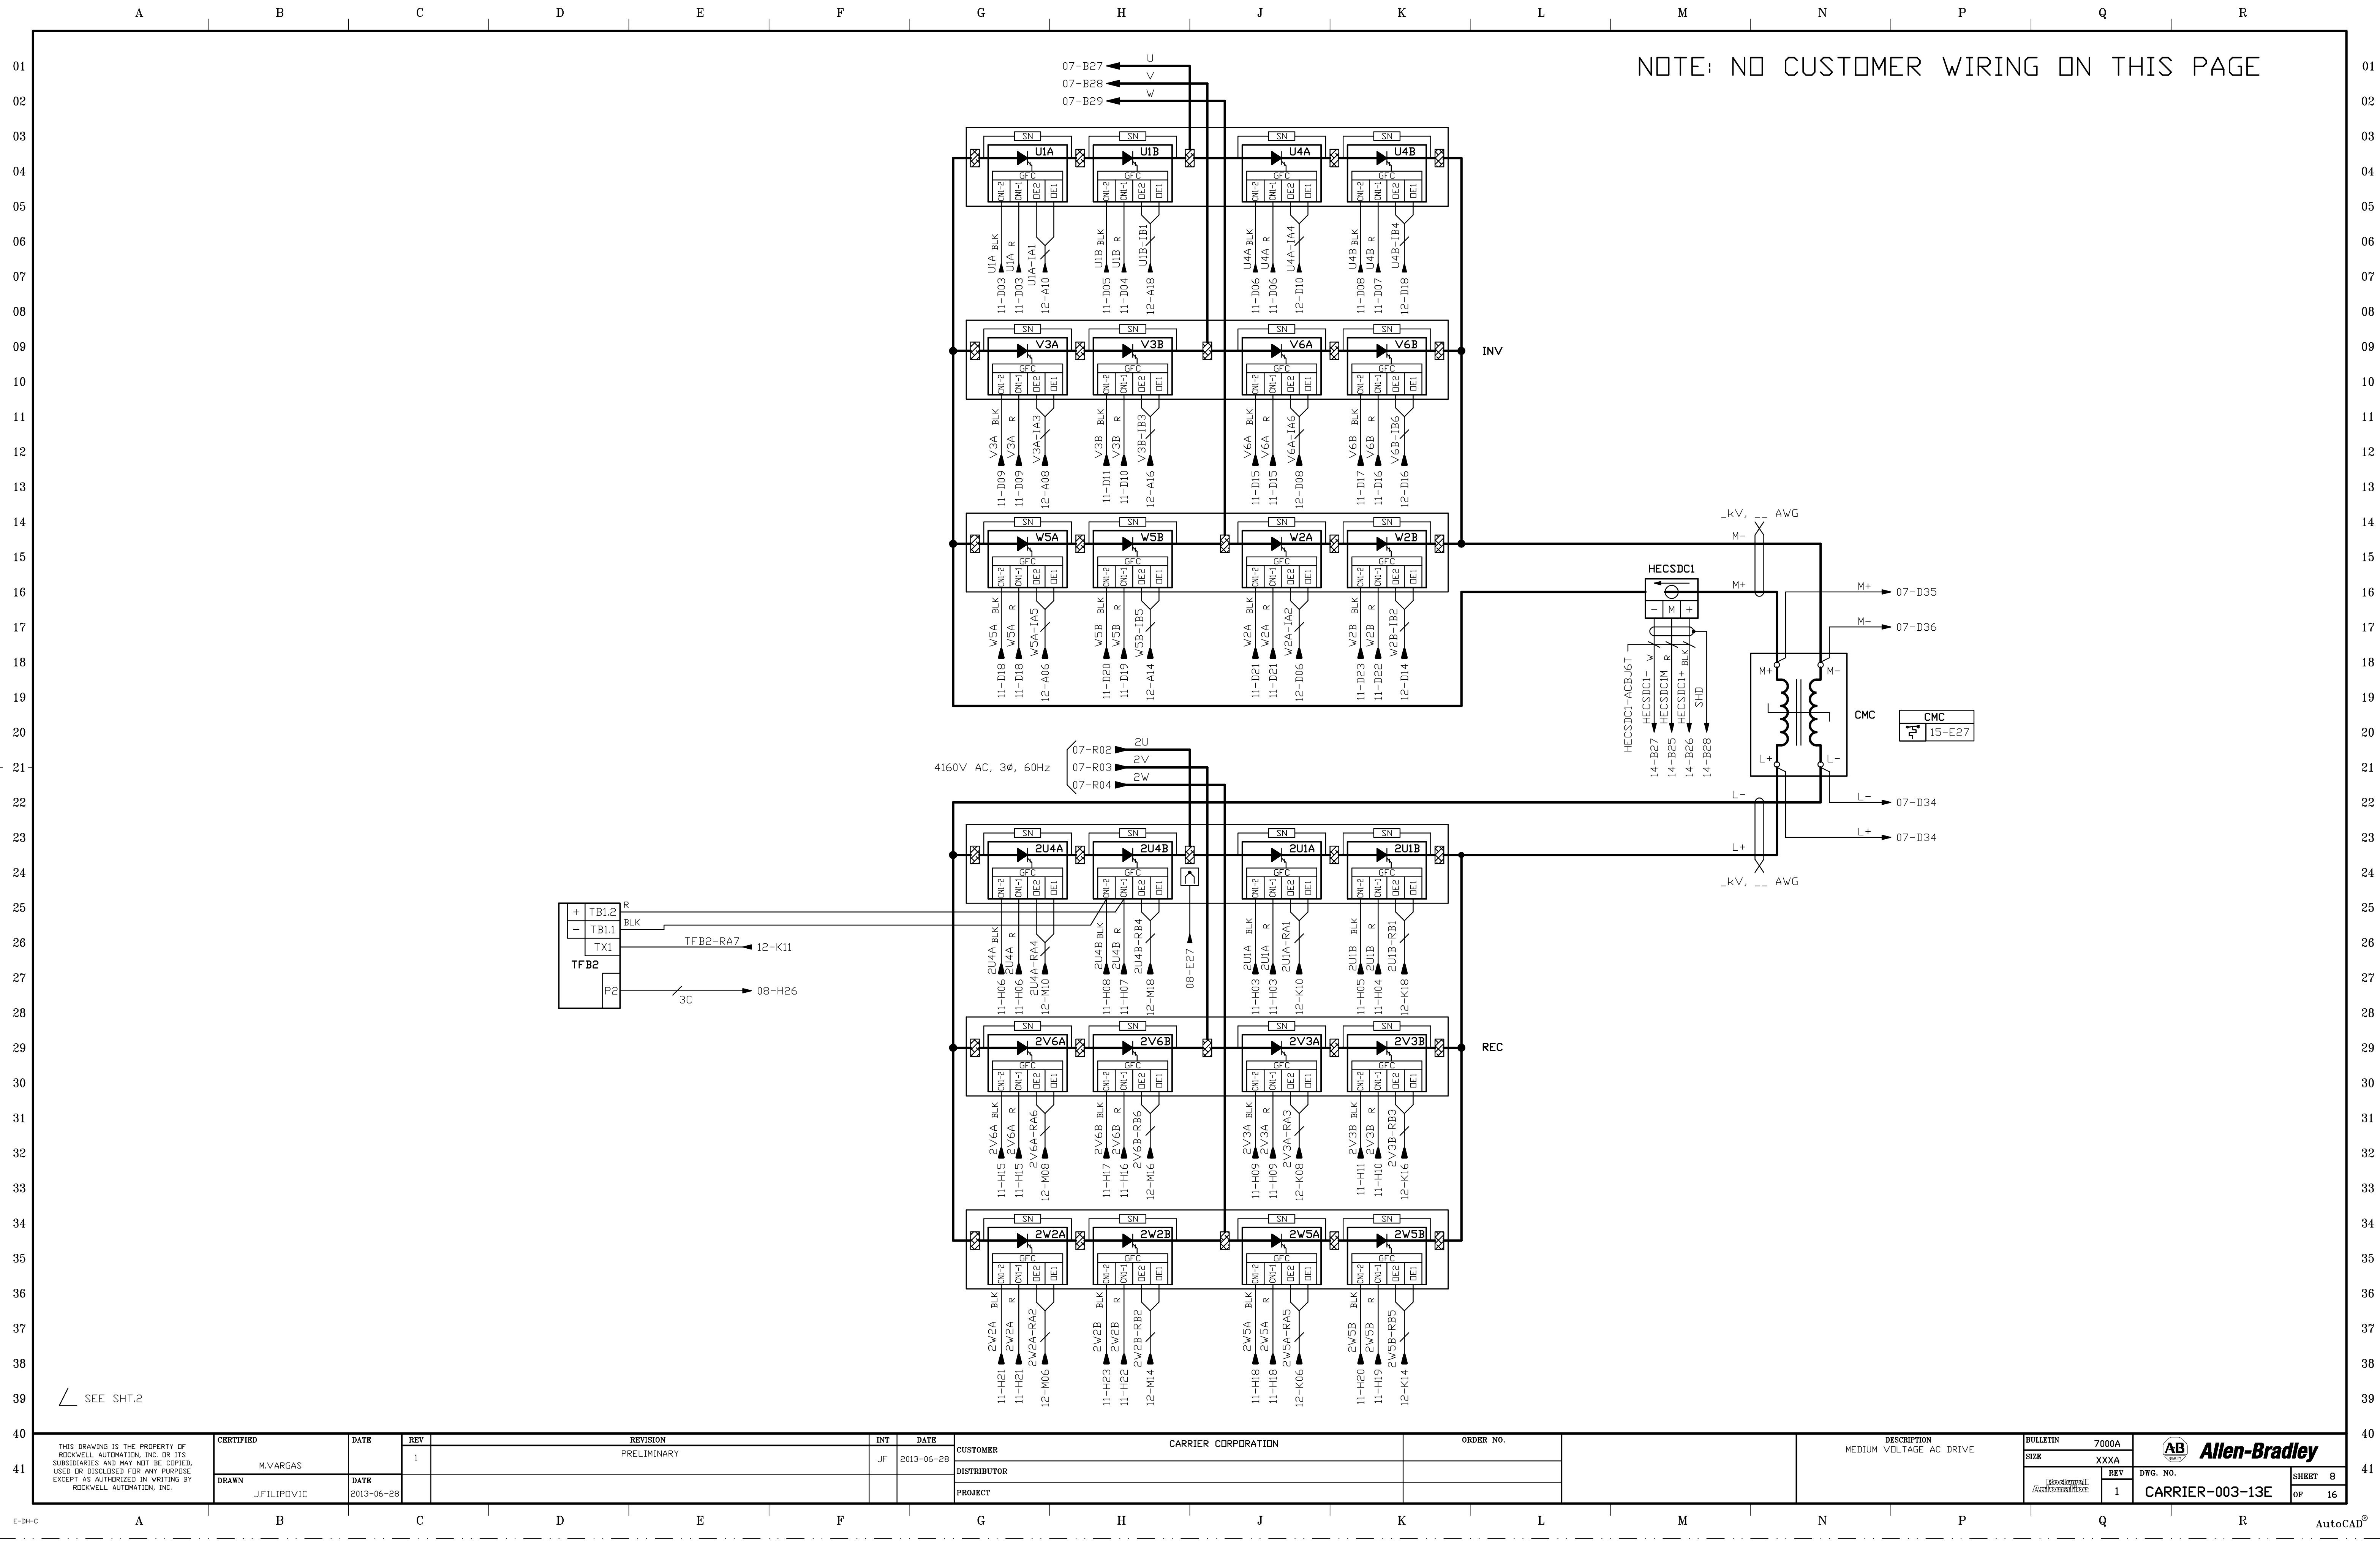

SEE SHT.2


THIS DRAWING IS THE PROPERTY OF ROCKWELL AUTOMATION, INC. OR ITS SUBSIDIARIES AND MAY NOT BE COPIED, USED OR DISCLOSED FOR ANY PURPOSE EXCEPT AS AUTHORIZED IN WRITING BY ROCKWELL AUTOMATION, INC.	CERTIFIED	DATE	REV	REVISION		INT	DATE	CUSTOMER		ORDER NO.		DESCRIPTION		BULLETIN		SIZE		REV		DWG. NO.		SHEET	
	M.VARGAS		1	PRELIMINARY		JF	2013-06-28	CARRIER CORPORATION				MEDIUM VOLTAGE AC DRIVE		7000A		XXXA						8	
	J.FILIPOVIC	2013-06-28						DISTRIBUTOR						1		CARRIER-003-13E		1		OF		16	
								PROJECT															

NOTE: NO CUSTOMER WIRING ON THIS PAGE

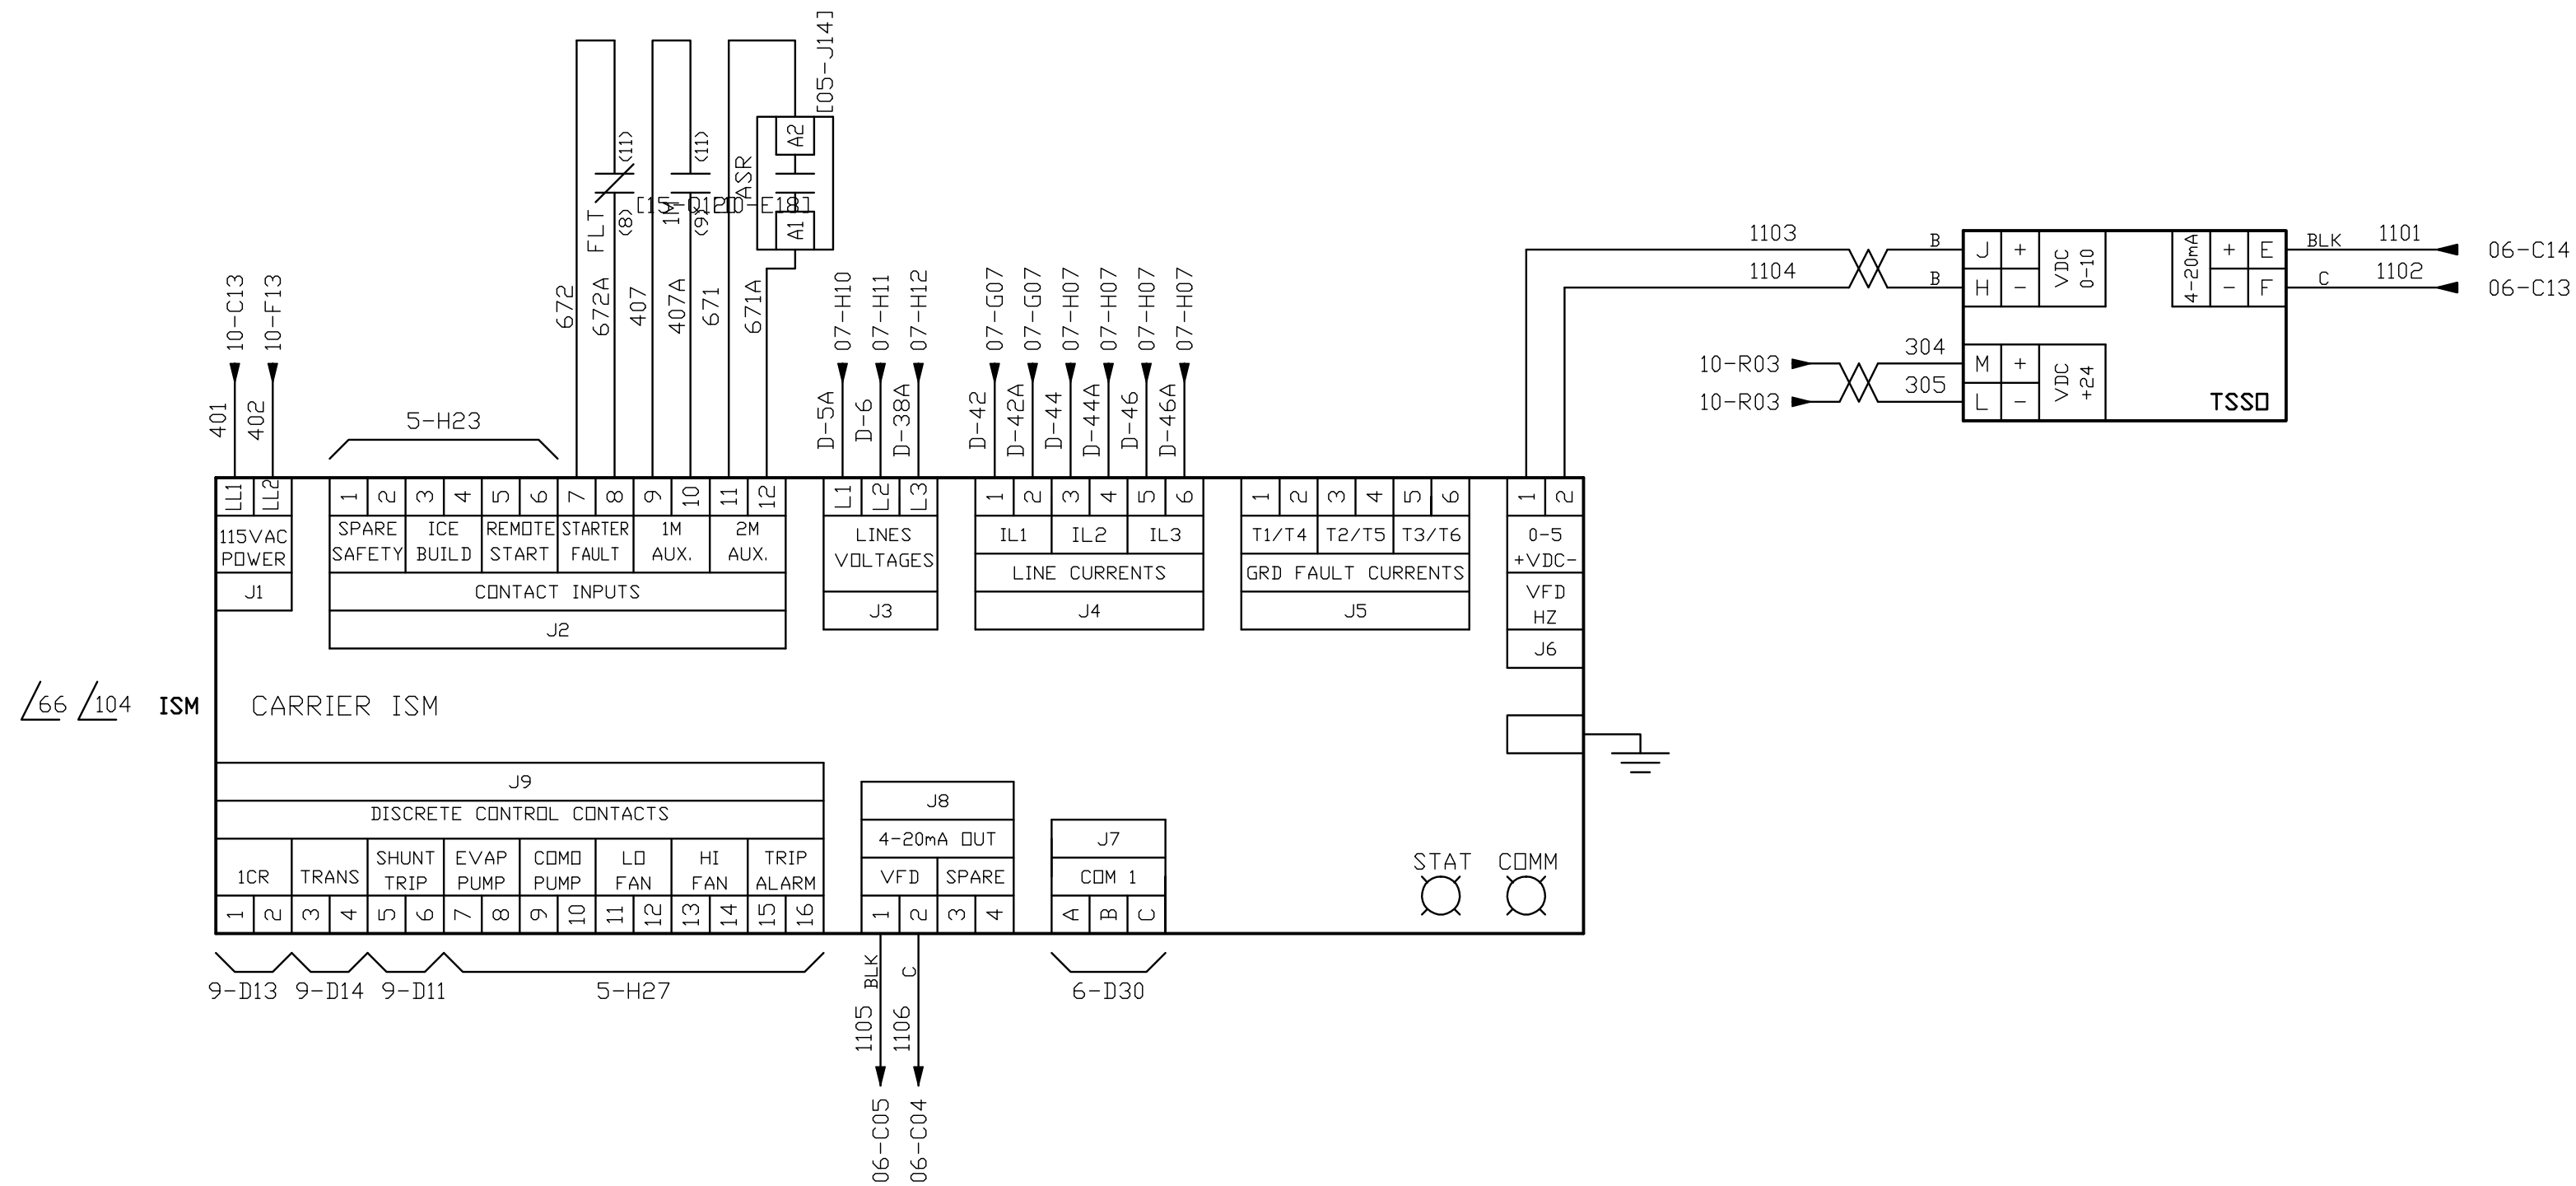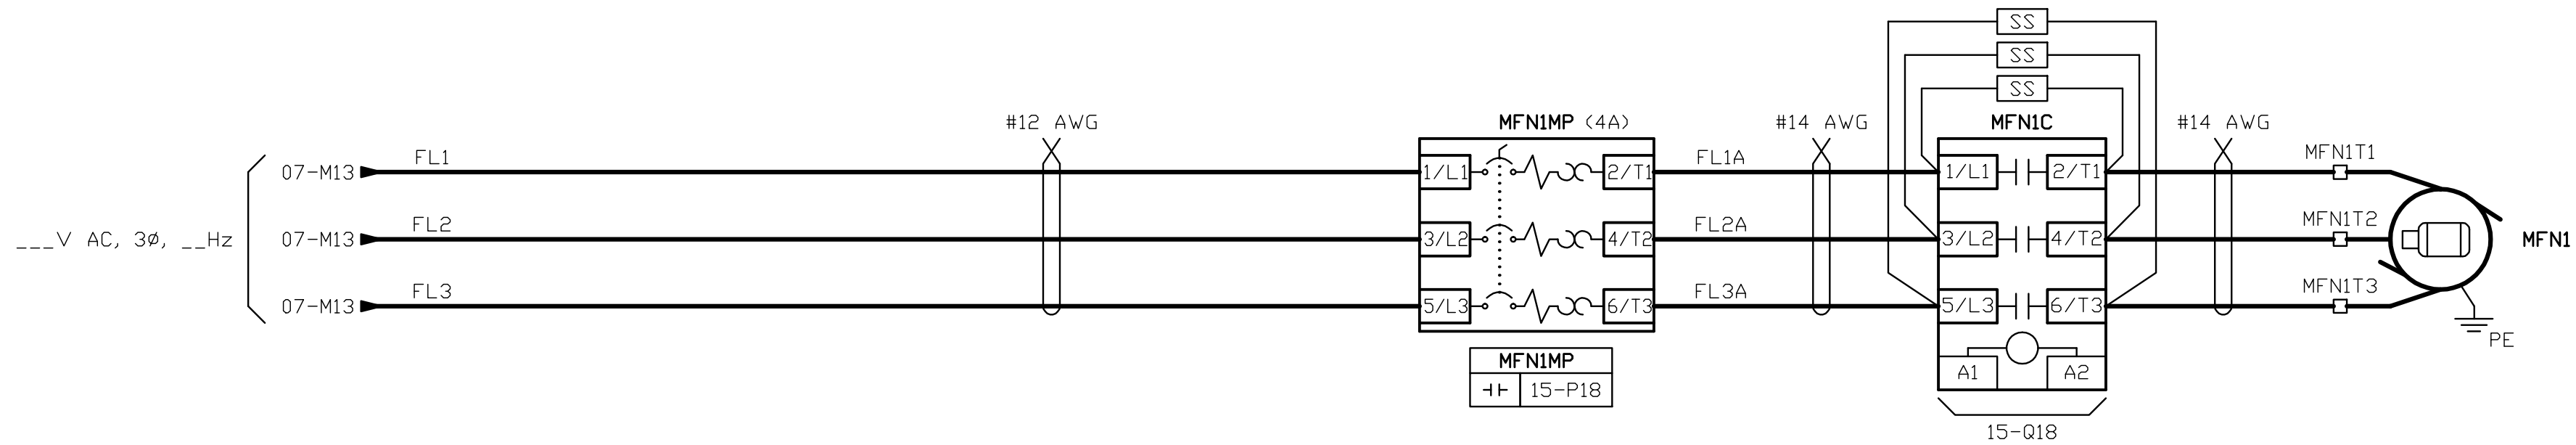


SEE SHT.2



THIS DRAWING IS THE PROPERTY OF ROCKWELL AUTOMATION, INC. OR ITS SUBSIDIARIES AND MAY NOT BE COPIED, USED OR DISCLOSED FOR ANY PURPOSE EXCEPT AS AUTHORIZED IN WRITING BY ROCKWELL AUTOMATION, INC.	CERTIFIED	DATE	REV	REVISION	INT	DATE	CUSTOMER	ORDER NO.	DESCRIPTION MEDIUM VOLTAGE AC DRIVE	BULLETIN	7000A		CARRIER-003-13E
	M.VARGAS		1	PRELIMINARY	JF	2013-06-28	CARRIER CORPORATION			SIZE	XXXA		
	DRAWN	DATE					DISTRIBUTOR			REV	1		
	J.FILIPOVIC	2013-06-28					PROJECT			DWG. NO.			SHEET 9
													OF 16

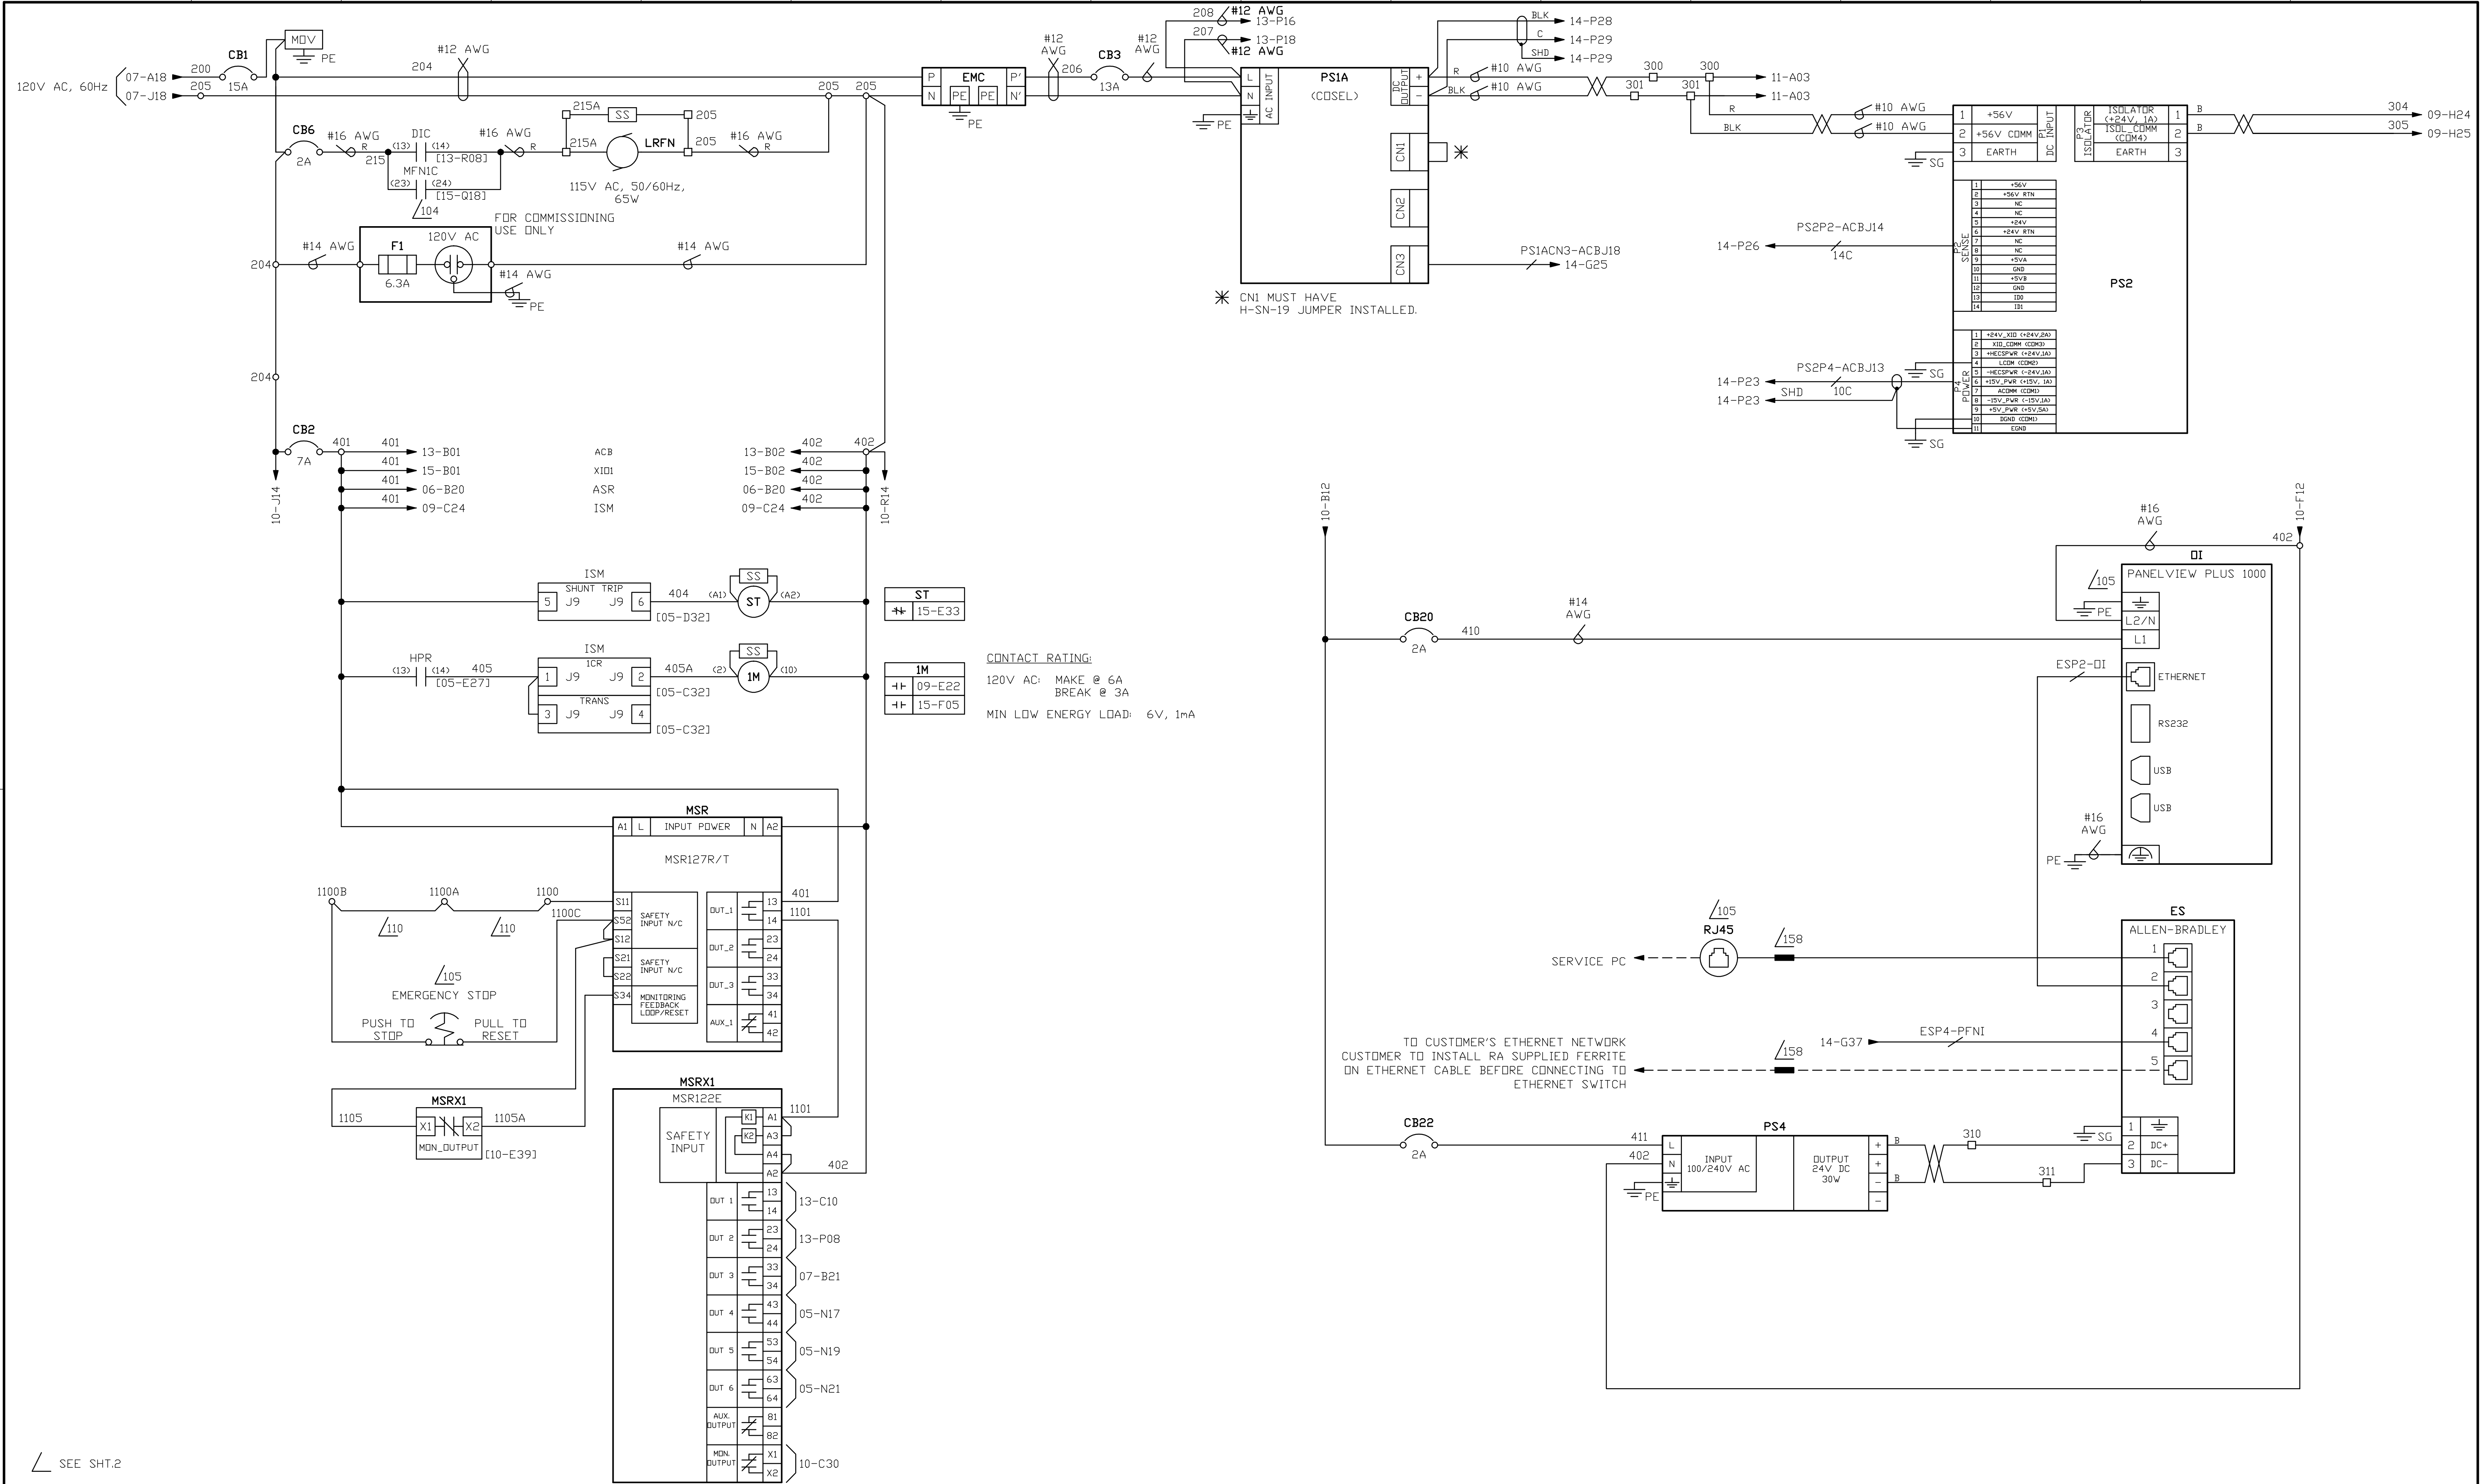


THIS DRAWING IS THE PROPERTY OF ROCKWELL AUTOMATION, INC. OR ITS SUBSIDIARIES AND MAY NOT BE COPIED, USED OR DISCLOSED FOR ANY PURPOSE EXCEPT AS AUTHORIZED IN WRITING BY ROCKWELL AUTOMATION, INC.	CERTIFIED	DATE	REV	REVISION	INT	DATE	CUSTOMER	ORDER NO.	MEDIUM VOLTAGE AC DRIVE	BULLETIN 7000A SIZE XXXA REV XXXX 1	DWC. NO. CARRIER-003-13E	SHEET 10 OF 16
	M.VARGAS		1	PRELIMINARY	JF	2013-06-28						
	DRAWN	DATE					DISTRIBUTOR					
	J.FILIPOVIC	2013-06-28					PROJECT					

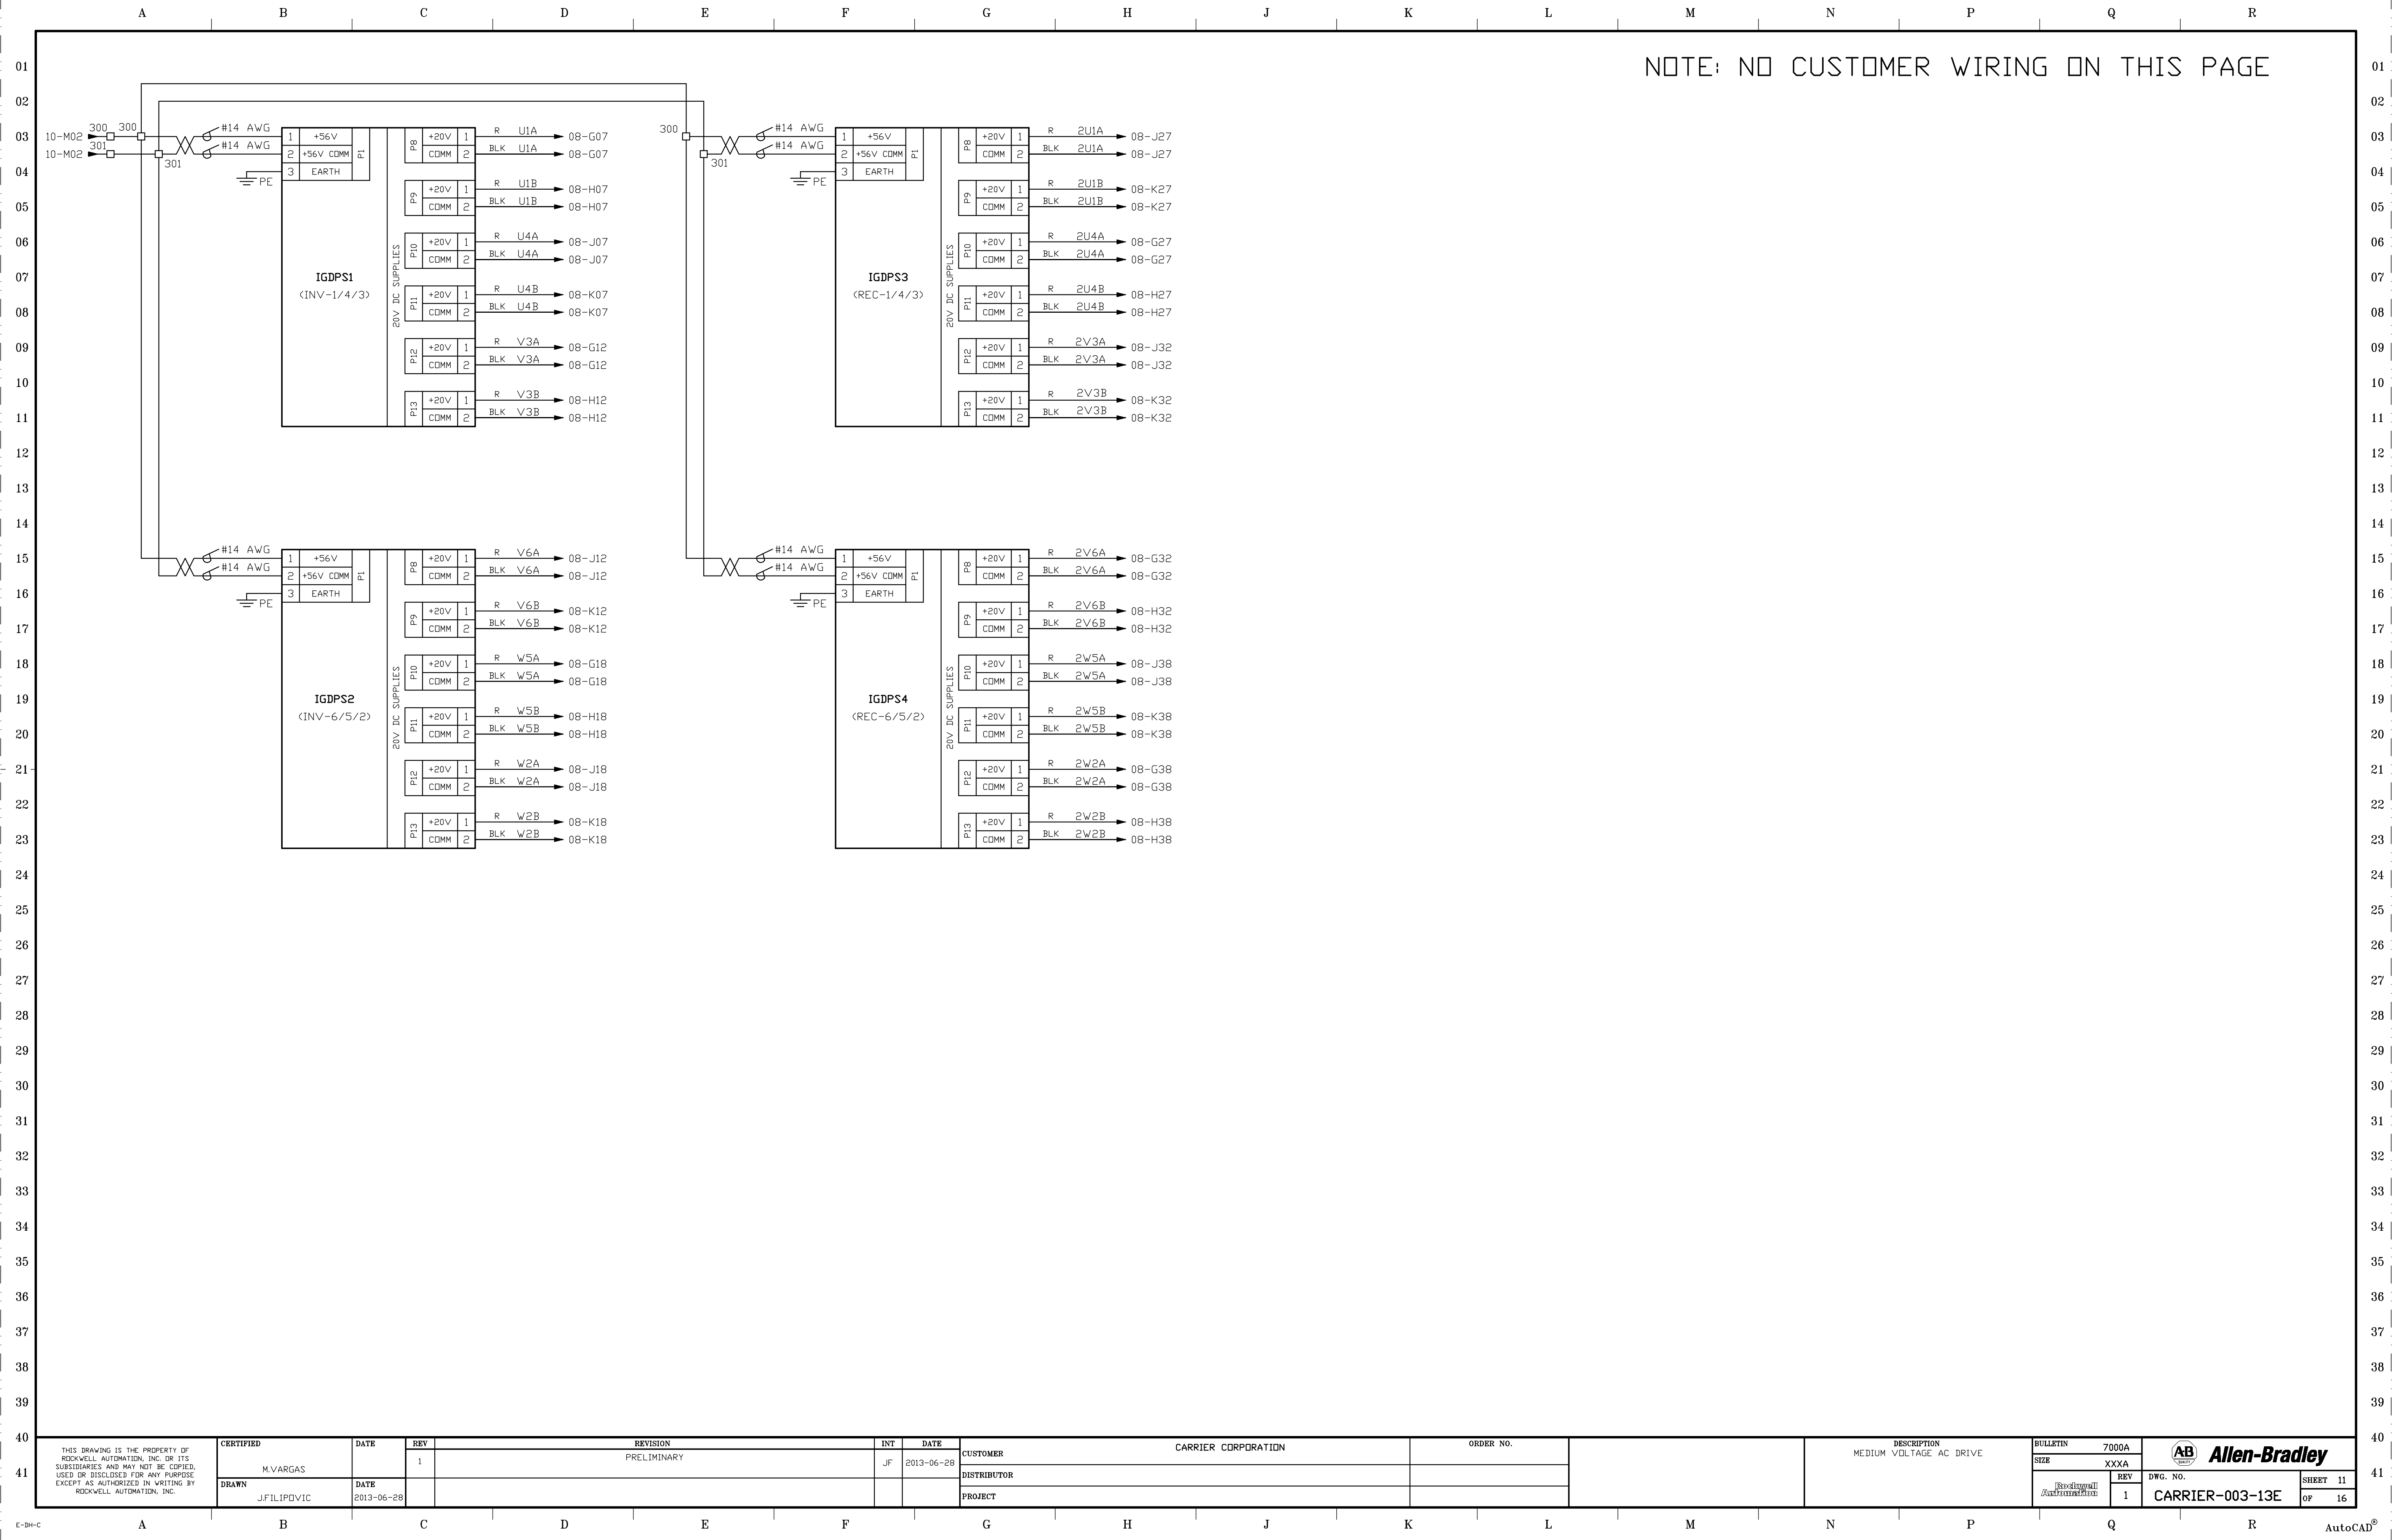


NOTE: NO CUSTOMER WIRING ON THIS PAGE

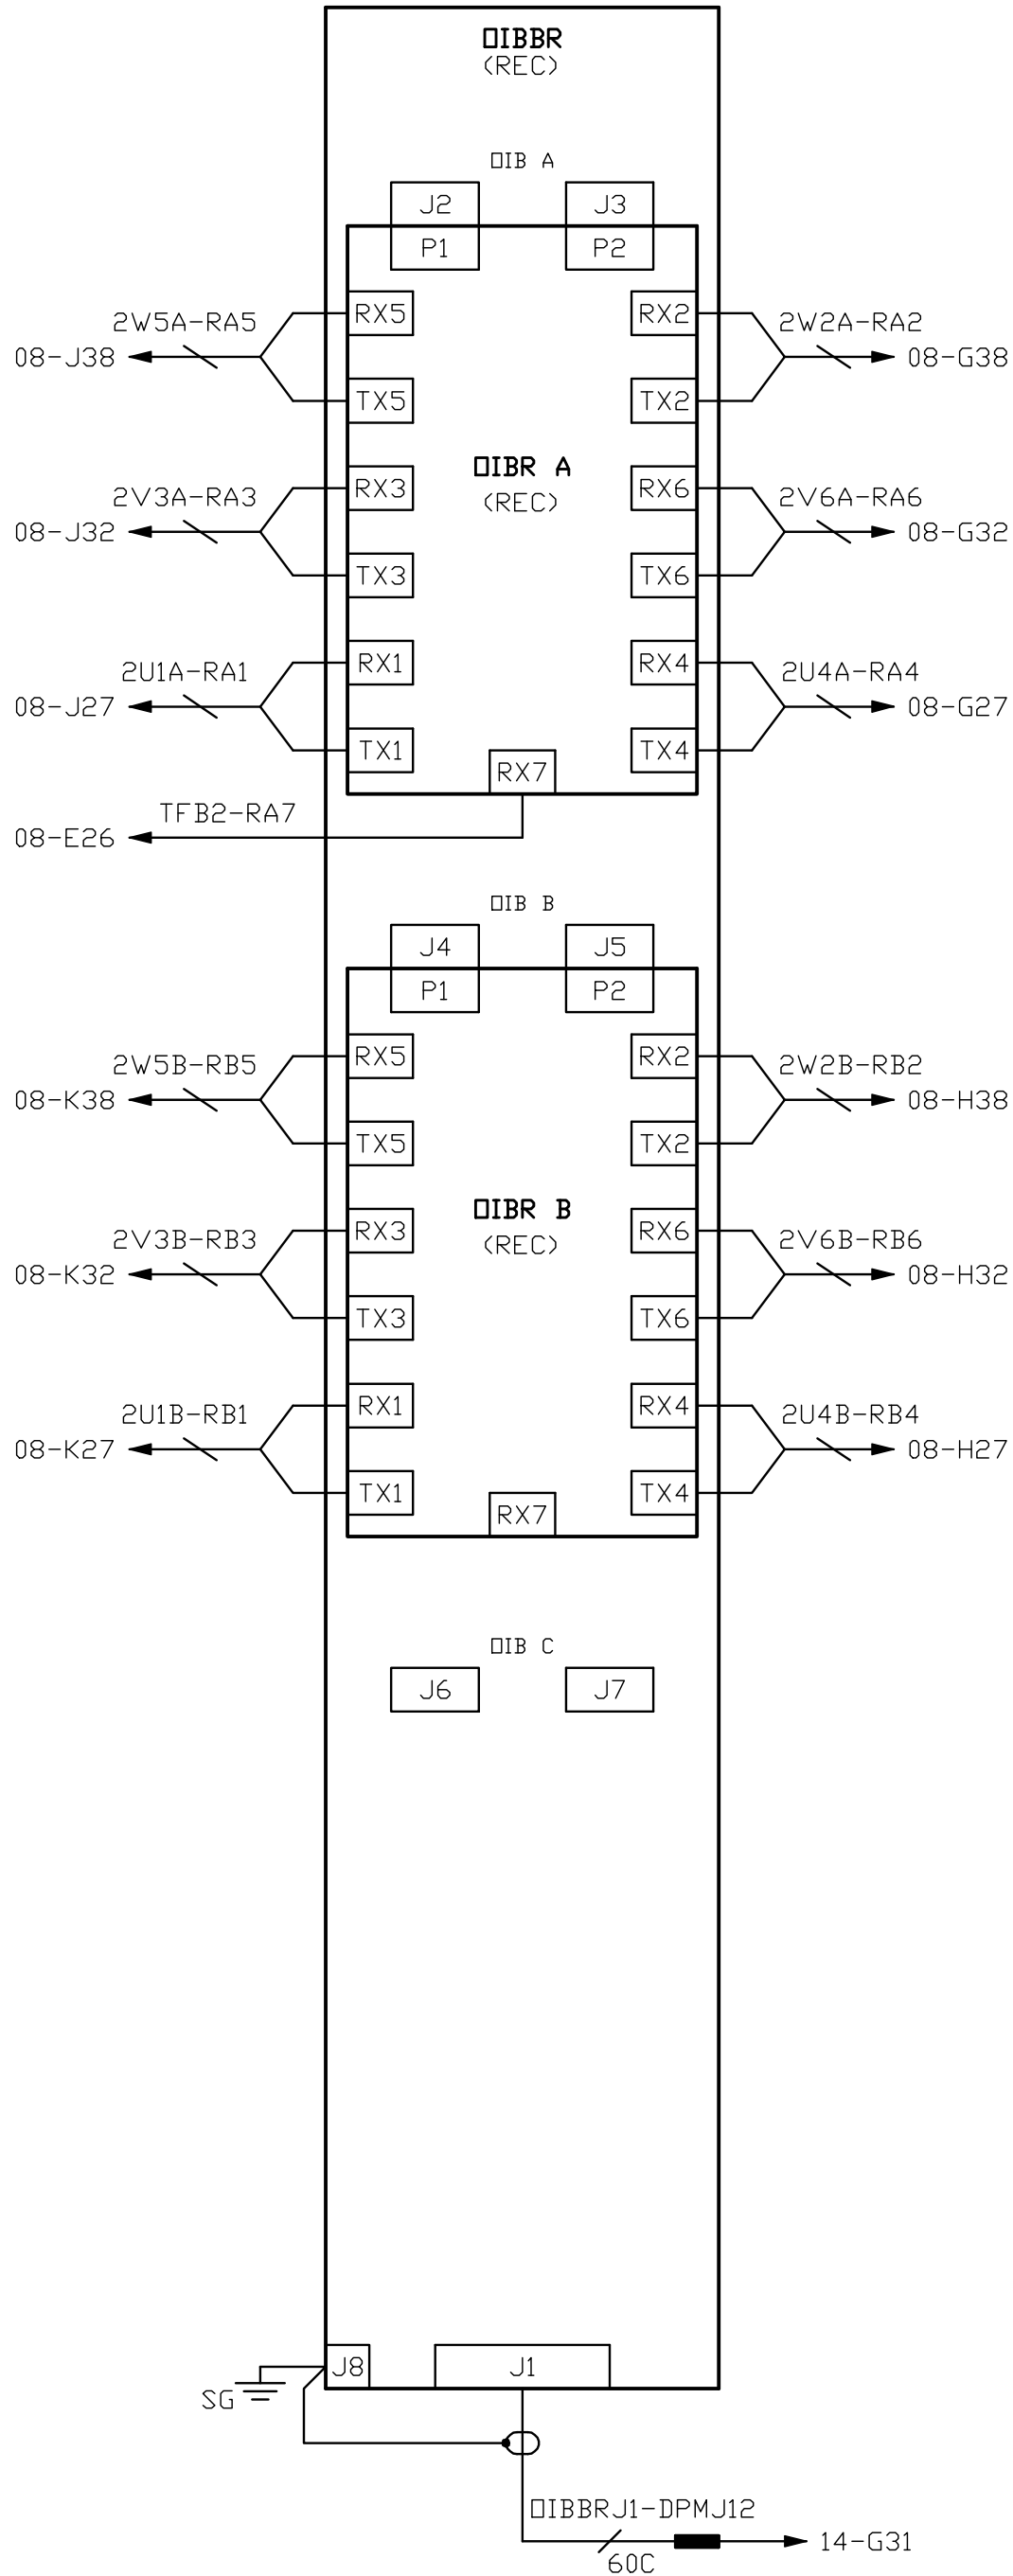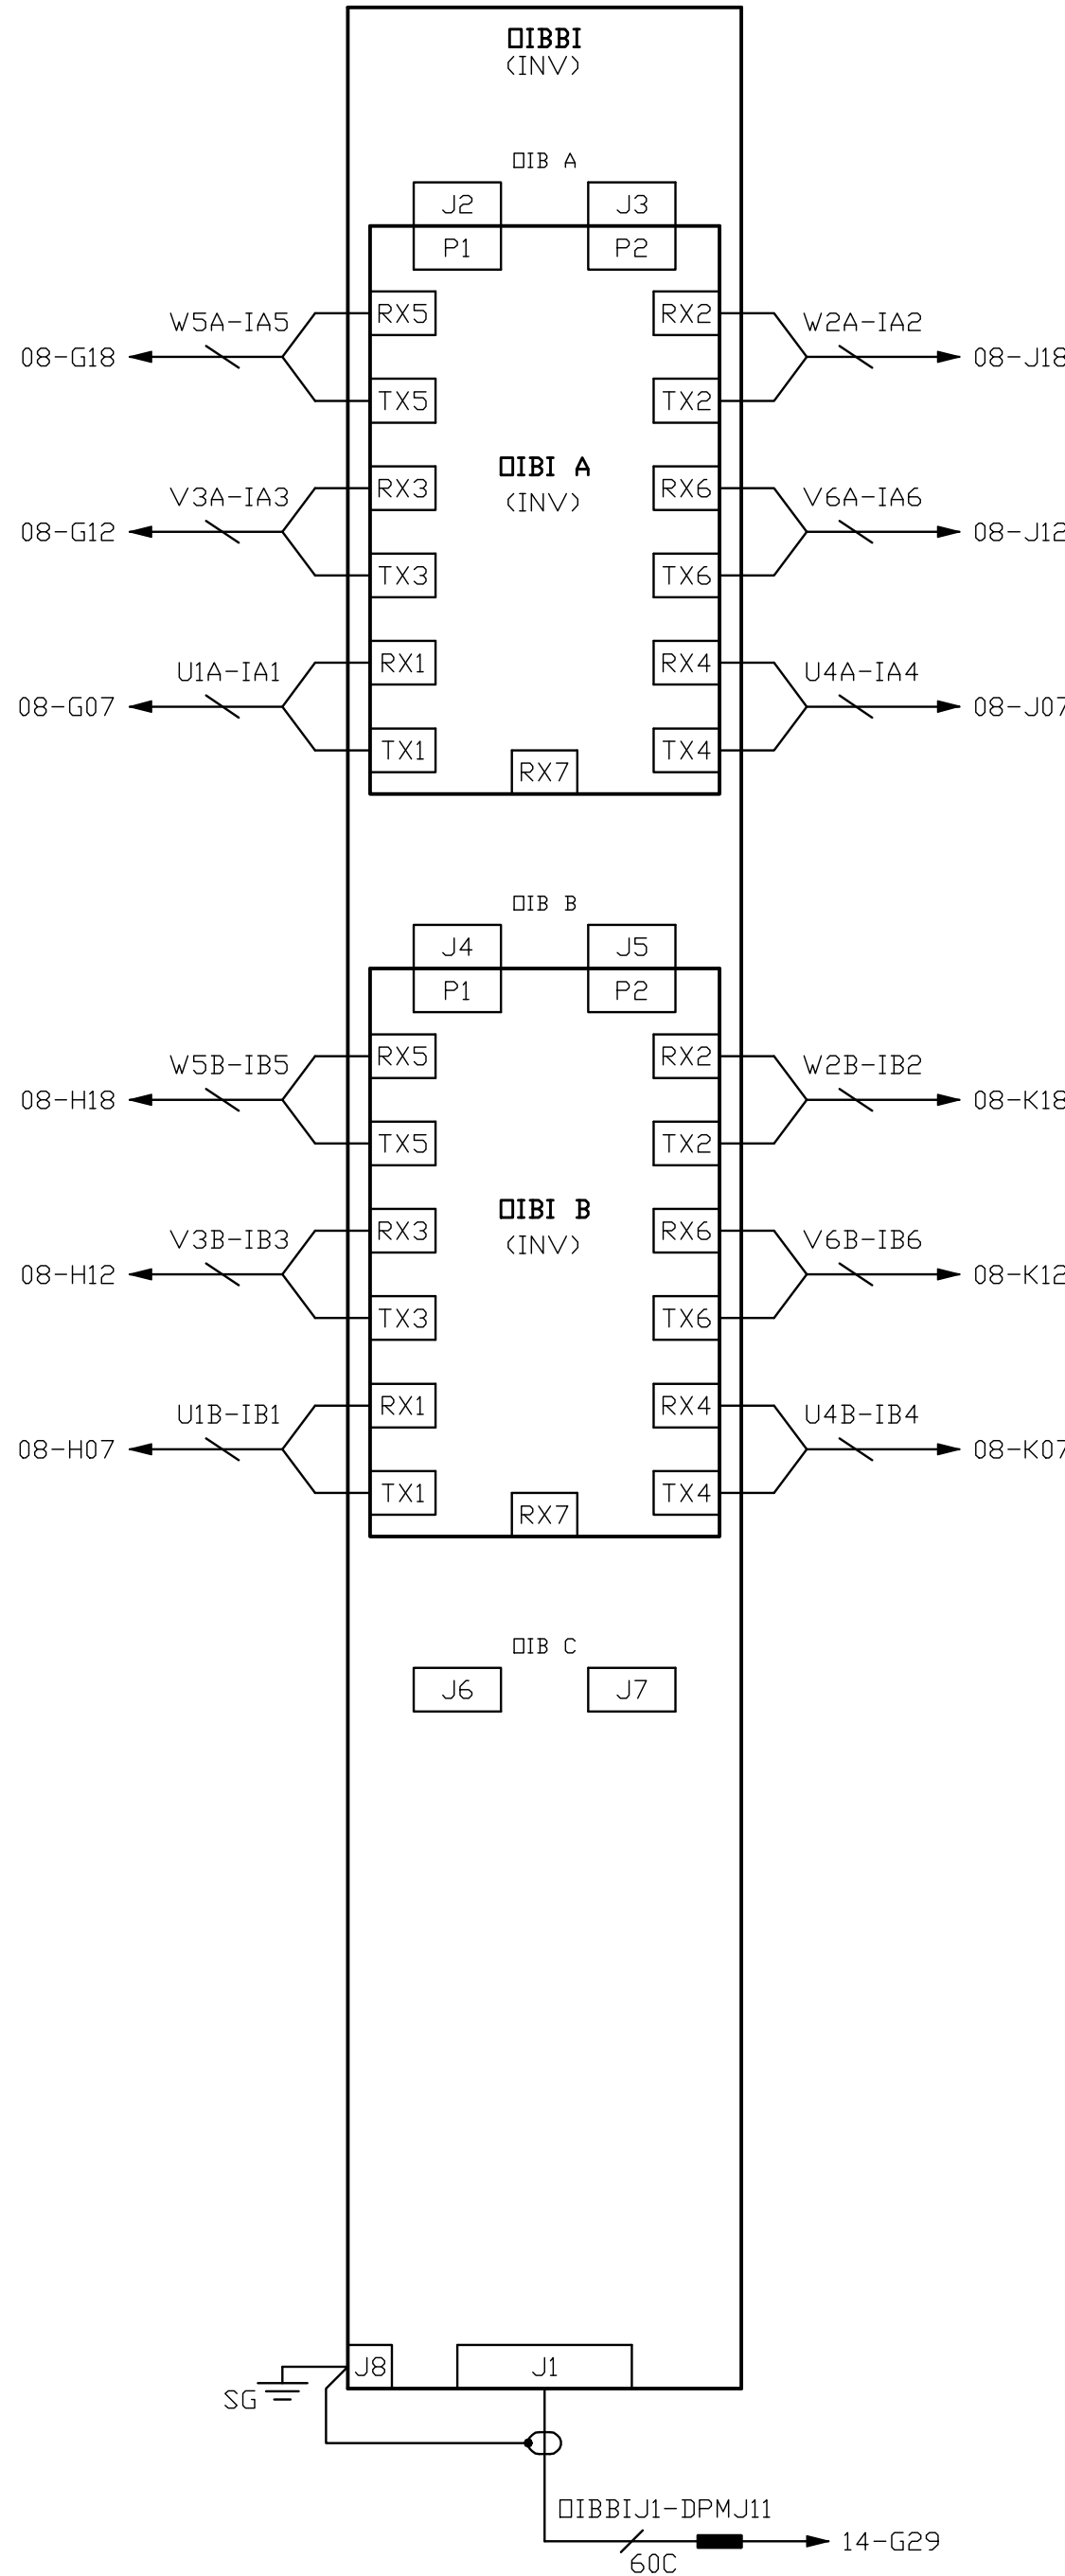

THIS DRAWING IS THE PROPERTY OF ROCKWELL AUTOMATION, INC. OR ITS SUBSIDIARIES AND MAY NOT BE COPIED, USED OR DISCLOSED FOR ANY PURPOSE EXCEPT AS AUTHORIZED IN WRITING BY ROCKWELL AUTOMATION, INC.	CERTIFIED	DATE	REV	REVISION	INT	DATE	CUSTOMER	ORDER NO.	DESCRIPTION MEDIUM VOLTAGE AC DRIVE	BULLETIN	7000A		CARRIER-003-13E
	M.VARGAS		1	PRELIMINARY	JF	2013-06-28	CARRIER CORPORATION			SIZE	XXXA		
	DRAWN J.FILIPOVIC	DATE 2013-06-28					DISTRIBUTOR			REV	1		
							PROJECT						SHEET 12 OF 16

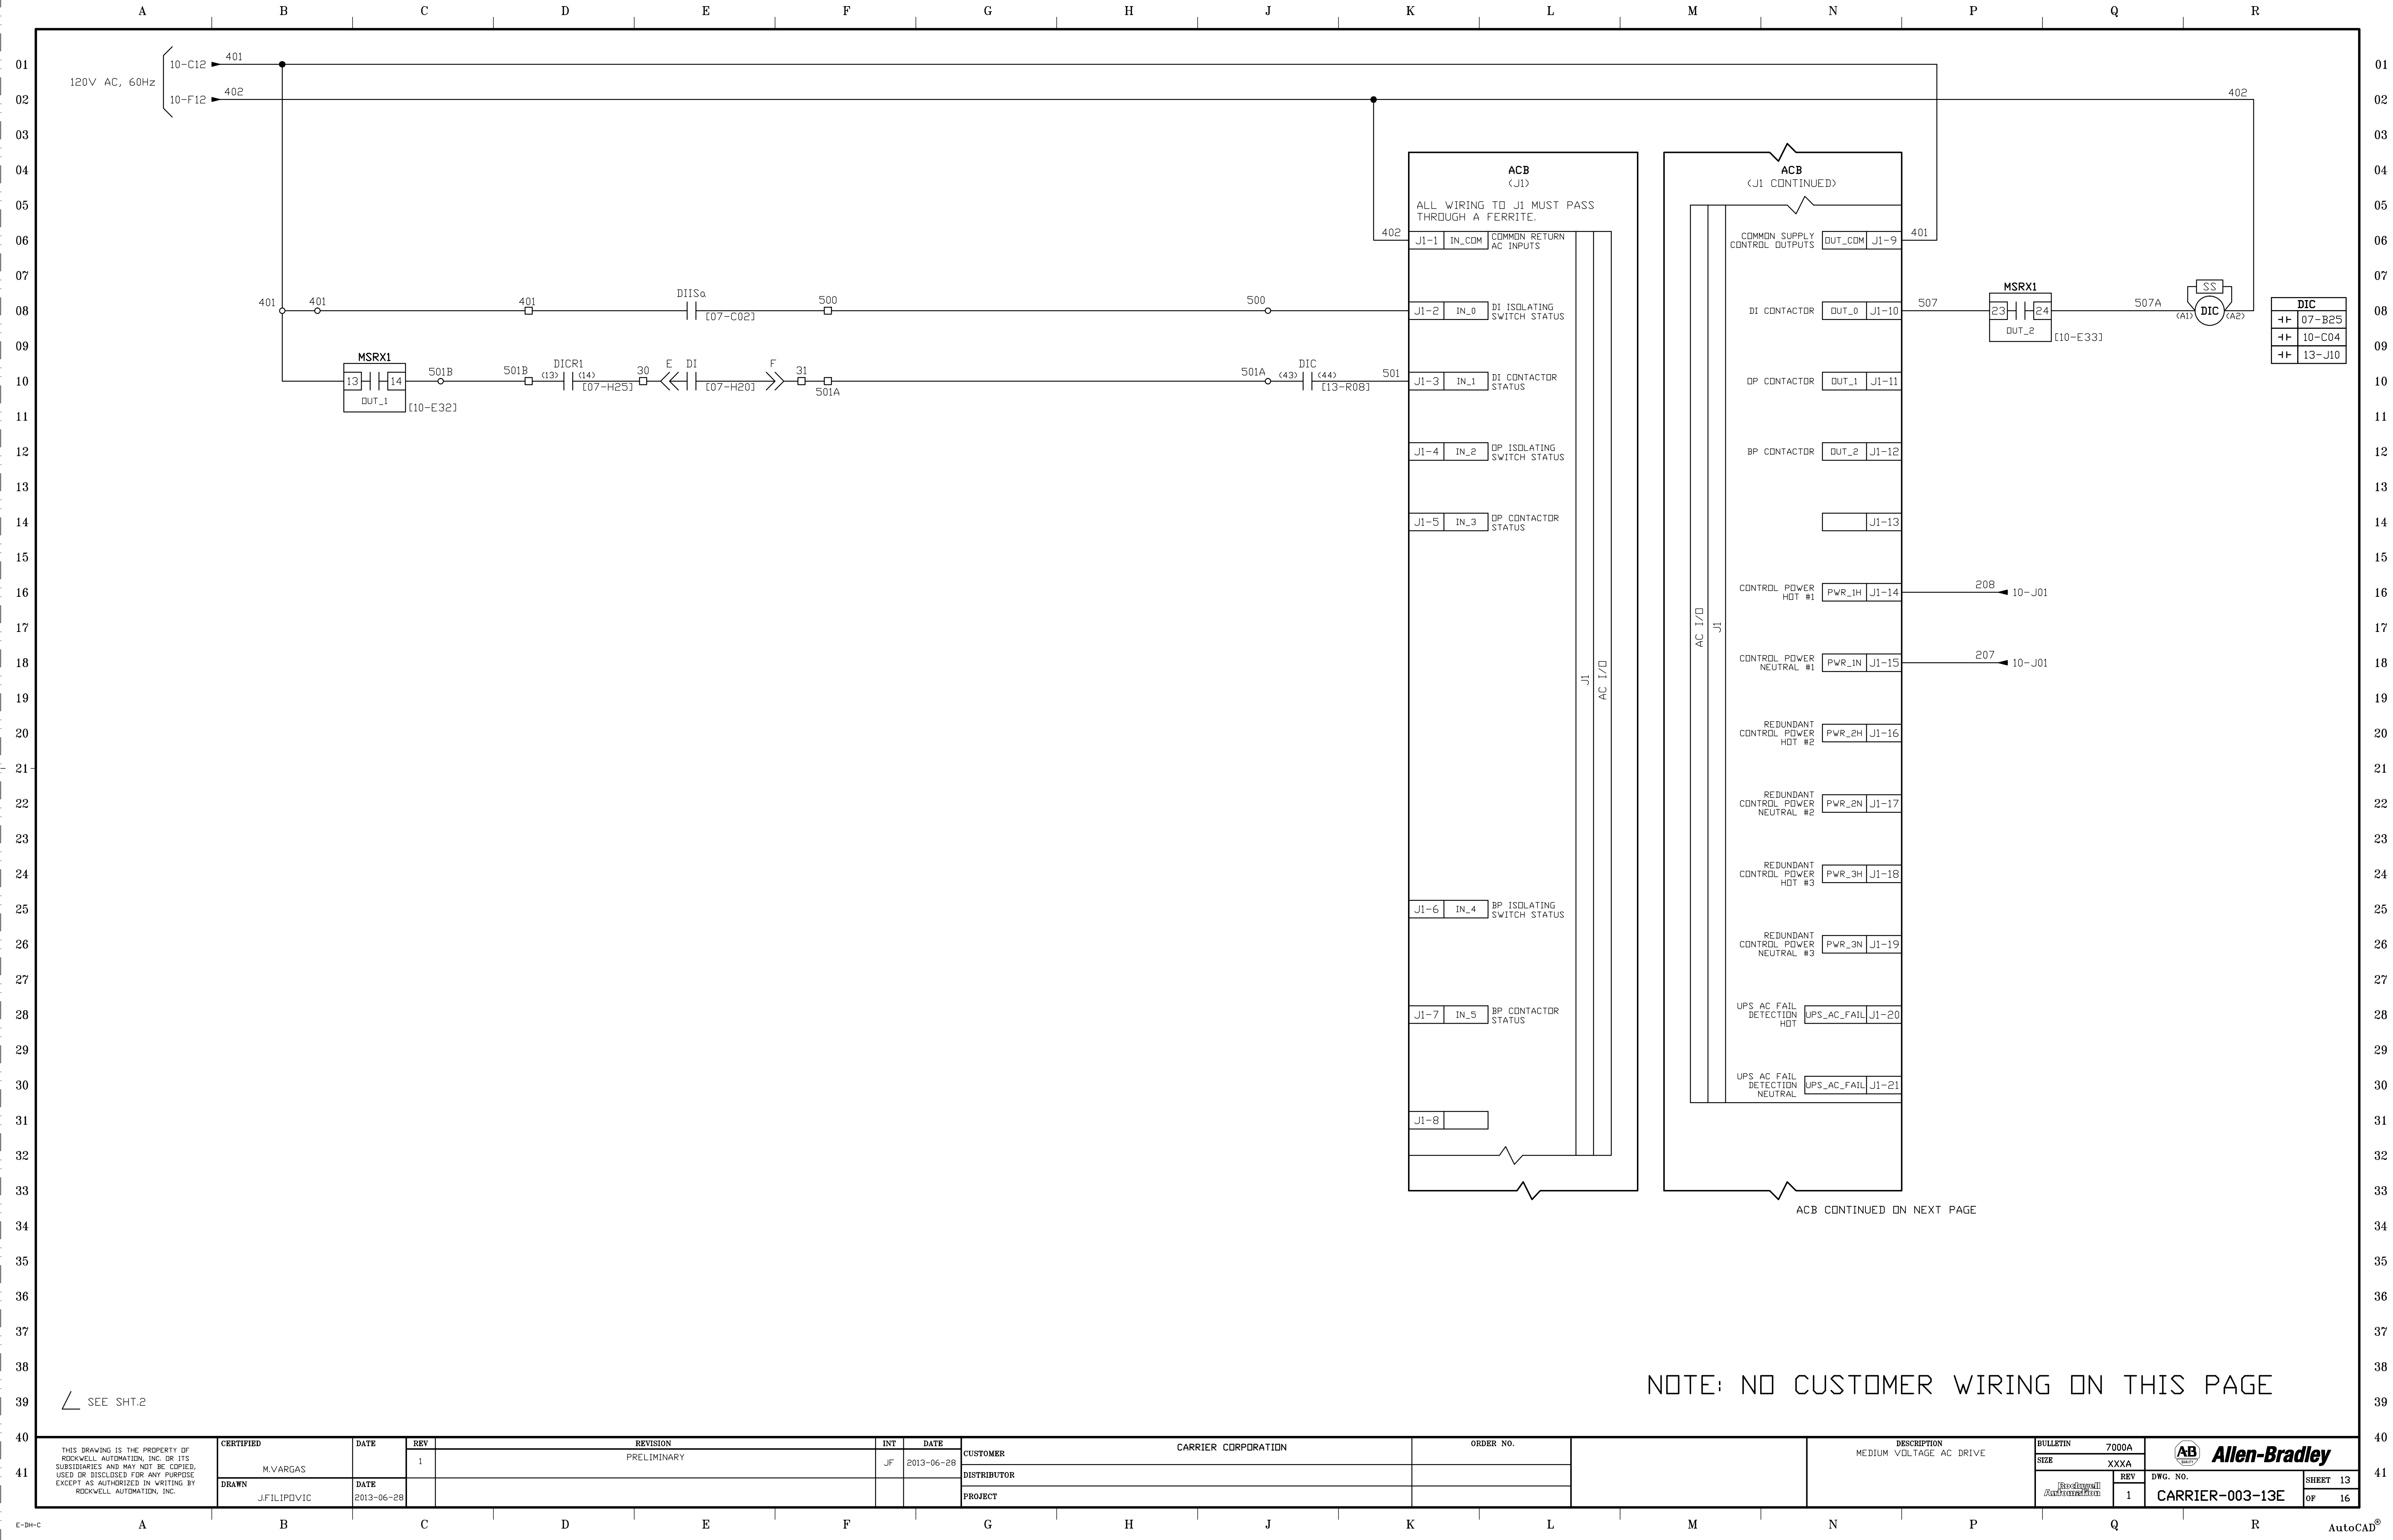

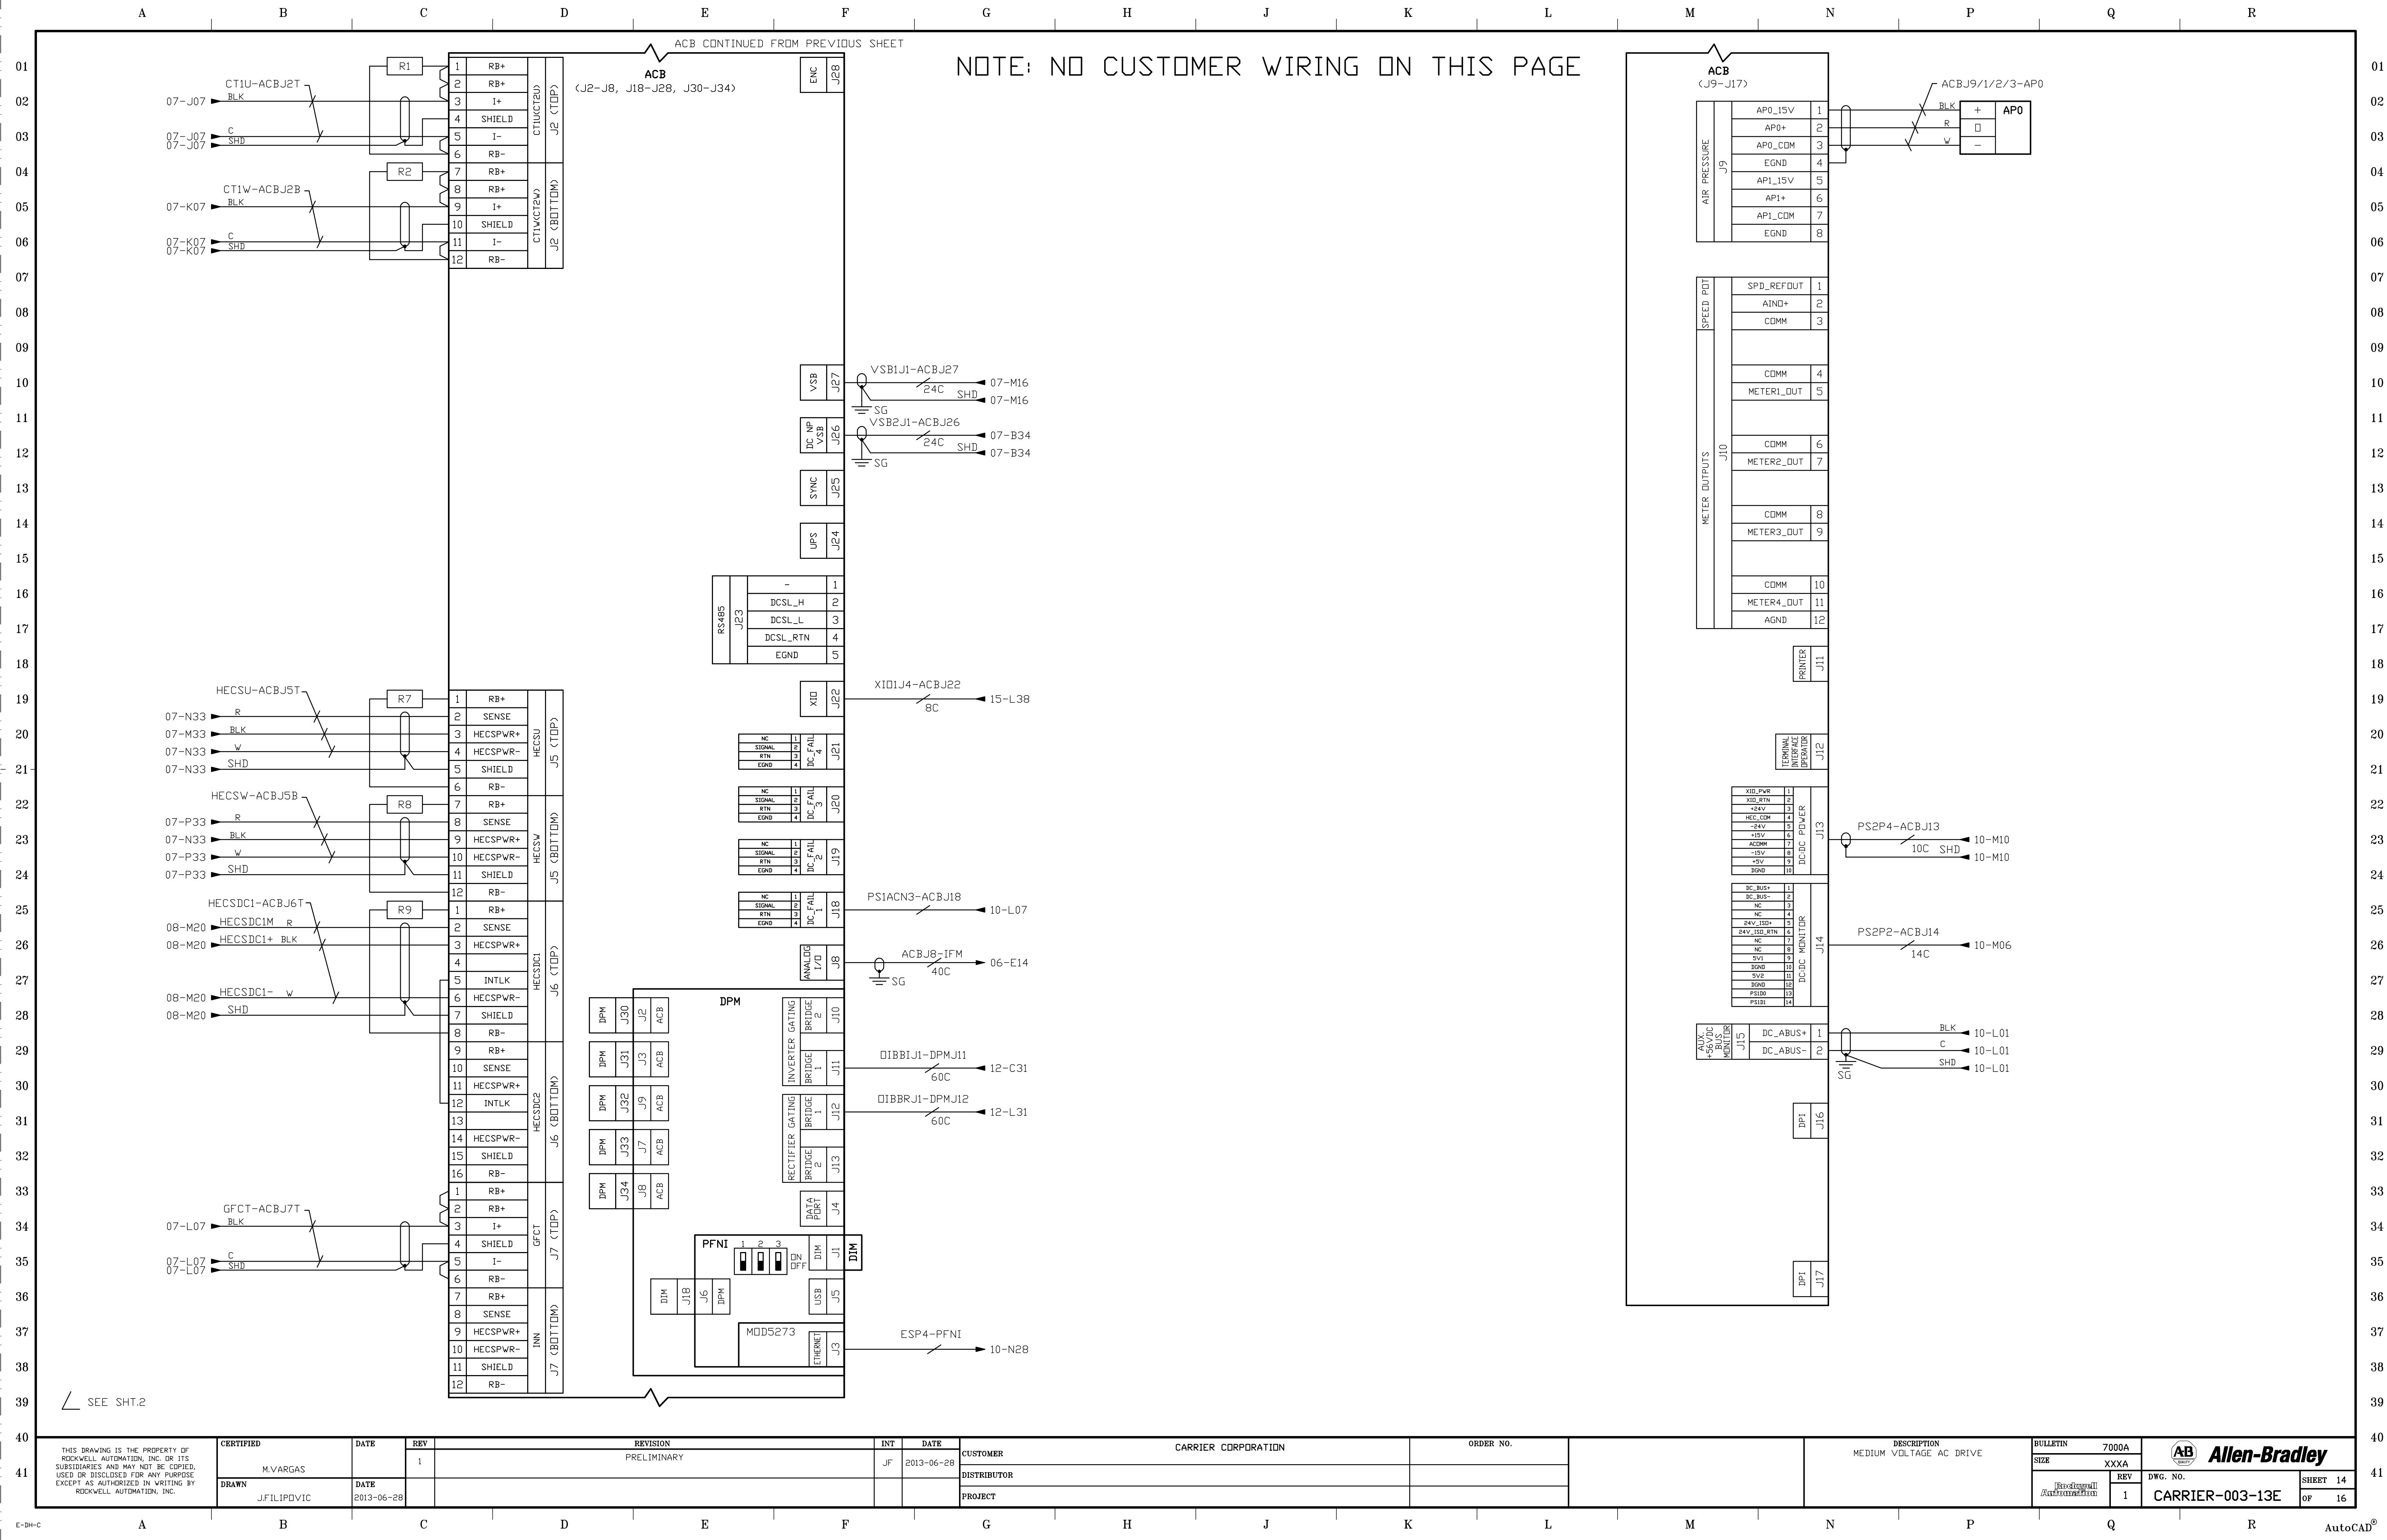



	A	B	C	D	E	F	G	H	J	K	L	M	N	P	Q	R																																																																																																																																																																																																																																																																																													
<table><tr><td colspan="3">WIRING</td><td colspan="3">SWITCHES AND INPUT DEVICES</td><td colspan="3">OUTPUT DEVICES</td><td colspan="3">RESISTORS, CAPS, WINDINGS AND GROUND</td><td colspan="3">PROTECTION</td></tr><tr><td>CONDUCTOR, OR CONDUCTIVE PATH</td><td></td><td></td><td>SWITCH, SINGLE THROW</td><td></td><td></td><td>COIL, OPERATING</td><td></td><td></td><td>CAPACITOR</td><td></td><td></td><td>CIRCUIT BREAKER, CONTROL/POWER</td><td></td><td></td></tr><tr><td>CONDUCTOR, ASSOCIATED OR FUTURE (NOT SUPPLIED BY ROCKWELL AUTOMATION)</td><td></td><td></td><td>SWITCH, TOGGLE (MAINTAINED POSITION) TRANSFER, SINGLE POLE</td><td></td><td></td><td>COIL, BLOWOUT</td><td></td><td></td><td>RESISTOR, GENERAL</td><td></td><td></td><td>FUSE, CONTROL/POWER</td><td></td><td></td></tr><tr><td>TEMPORARY WIRING</td><td></td><td></td><td>PUSHBUTTON</td><td></td><td></td><td>FAN (3Ø INDUCTION MOTOR)</td><td></td><td></td><td>RESISTOR, ADJUSTABLE (POTENTIOMETER)</td><td></td><td></td><td>OVERLOAD RELAY, THERMAL</td><td></td><td></td></tr><tr><td>COPPER BUS BAR</td><td></td><td></td><td>SWITCH, MUSHROOM HEAD, (MAINTAINED)</td><td></td><td></td><td>FAN (1Ø INDUCTION MOTOR)</td><td></td><td></td><td>REACTOR, SATURABLE CORE</td><td></td><td></td><td>SURGE SUPPRESSOR</td><td></td><td></td></tr><tr><td>MECHANICALLY CONNECTED</td><td></td><td></td><td>CONTACT</td><td></td><td></td><td>INDUCTION MACHINE</td><td></td><td></td><td>WINDING</td><td></td><td></td><td>SWITCH, DISCONNECT (FUSED)</td><td></td><td></td></tr><tr><td>CABLE, MULTICONDUCTOR</td><td></td><td></td><td>ON-DELAY TIMED CONTACT</td><td></td><td></td><td>INDUCTION MACHINE (SYNCHRONOUS)</td><td></td><td></td><td>TRANSFORMER, WITH MAGNETIC CORE</td><td></td><td></td><td>SWITCH, DISCONNECT (NON FUSED)</td><td></td><td></td></tr><tr><td>CONDUCTOR, CROSSING OF PATHS OR CONDUCTORS NOT CONNECTED</td><td></td><td></td><td>OFF-DELAY TIMED CONTACT</td><td></td><td></td><td>LIGHT, INDICATING (PILOT, SIGNALLING, OR SWITCHBOARD)</td><td></td><td></td><td>TRANSFORMER, CURRENT</td><td></td><td></td><td>VARISTOR</td><td></td><td></td></tr><tr><td>CONDUCTOR, JUNCTION OF CONNECTED PATHS, CONDUCTORS OR WIRES</td><td></td><td></td><td>SWITCH, FLOW - ACTUATED, CLOSES ON INCREASE IN FLOW</td><td></td><td></td><td>LIGHT, INDICATING PUSH-TO-TEST</td><td></td><td></td><td>HALL EFFECT CURRENT SENSOR</td><td></td><td></td><td>THERMOCOUPLE</td><td></td><td></td></tr><tr><td>CONDUCTOR, SHIELDED SINGLE OR MULTICONDUCTOR</td><td></td><td></td><td>SWITCH, LIQUID LEVEL ACTUATED (FLDAT) CLOSING ON RISING LEVEL</td><td></td><td></td><td>LIGHT, INDICATING (LED TYPE)</td><td></td><td></td><td>GROUND</td><td></td><td></td><td>HEATSINK</td><td></td><td></td></tr><tr><td>CONDUCTORS, TWISTED</td><td></td><td></td><td>SWITCH, PRESSURE OR VACUUM OPERATED CLOSING ON RISING PRESSURE</td><td></td><td></td><td>METER (* : METER'S FUNCTION)</td><td></td><td></td><td>FERRITE</td><td></td><td></td><td></td><td></td><td></td></tr><tr><td>WIRE GAUGE MARKER</td><td></td><td></td><td>SWITCH, TEMPERATURE ACTUATED, OPENING ON RISING TEMPERATURE</td><td></td><td></td><td>RECEPTACLE</td><td></td><td></td><td>GROUNDING BALL</td><td></td><td></td><td></td><td></td><td></td></tr><tr><td>CONNECTOR, SEPARABLE OR JACKS ENGAGED</td><td></td><td></td><td>SWITCH, SELECTOR (MULTIPOSITION) WITH CONTACT CLOSED INDICATOR X - INDICATES CONTACTS CLOSE</td><td></td><td></td><td>PLC OUTPUT</td><td></td><td></td><td></td><td></td><td></td><td></td><td></td><td></td></tr><tr><td>TERMINAL</td><td></td><td></td><td>SWITCH, SELECTOR (MULTIPOSITION) WITH PUSHBUTTON TYPE CONTACT MECHANISM X - INDICATES CONTACTS CLOSED</td><td></td><td></td><td>GENERATOR</td><td></td><td></td><td colspan="3">POWER ELECTRONIC DEVICES</td><td></td><td></td><td></td></tr><tr><td>TERMINAL (ROCKWELL AUTOMATION USE ONLY)</td><td></td><td></td><td>PLC INPUT</td><td></td><td></td><td></td><td></td><td></td><td>DIODE, SEMICONDUCTOR</td><td></td><td></td><td></td><td></td><td></td></tr><tr><td>TERMINAL BLOCKS</td><td></td><td></td><td></td><td></td><td></td><td></td><td></td><td></td><td>RECTIFIER SILICON CONTROLLED</td><td></td><td></td><td></td><td></td><td></td></tr><tr><td>— BARRIER</td><td></td><td></td><td></td><td></td><td></td><td></td><td></td><td></td><td>SYMMETRICAL GATE-COMMUTATED THYRISTOR AND GATE DRIVER BOARD</td><td></td><td></td><td></td><td></td><td></td></tr><tr><td>E - END BARRIER</td><td></td><td></td><td></td><td></td><td></td><td></td><td></td><td></td><td>RECTIFIER, FULL WAVE BRIDGE</td><td></td><td></td><td></td><td></td><td></td></tr><tr><td>WIRED TO / FROM DESTINATION (ARROW DIRECTION RELATIVE TO FLOW OF DRAWING ONLY)</td><td></td><td></td><td></td><td></td><td></td><td></td><td></td><td></td><td></td><td></td><td></td><td></td><td></td><td></td></tr></table>																	WIRING			SWITCHES AND INPUT DEVICES			OUTPUT DEVICES			RESISTORS, CAPS, WINDINGS AND GROUND			PROTECTION			CONDUCTOR, OR CONDUCTIVE PATH			SWITCH, SINGLE THROW			COIL, OPERATING			CAPACITOR			CIRCUIT BREAKER, CONTROL/POWER			CONDUCTOR, ASSOCIATED OR FUTURE (NOT SUPPLIED BY ROCKWELL AUTOMATION)			SWITCH, TOGGLE (MAINTAINED POSITION) TRANSFER, SINGLE POLE			COIL, BLOWOUT			RESISTOR, GENERAL			FUSE, CONTROL/POWER			TEMPORARY WIRING			PUSHBUTTON			FAN (3Ø INDUCTION MOTOR)			RESISTOR, ADJUSTABLE (POTENTIOMETER)			OVERLOAD RELAY, THERMAL			COPPER BUS BAR			SWITCH, MUSHROOM HEAD, (MAINTAINED)			FAN (1Ø INDUCTION MOTOR)			REACTOR, SATURABLE CORE			SURGE SUPPRESSOR			MECHANICALLY CONNECTED			CONTACT			INDUCTION MACHINE			WINDING			SWITCH, DISCONNECT (FUSED)			CABLE, MULTICONDUCTOR			ON-DELAY TIMED CONTACT			INDUCTION MACHINE (SYNCHRONOUS)			TRANSFORMER, WITH MAGNETIC CORE			SWITCH, DISCONNECT (NON FUSED)			CONDUCTOR, CROSSING OF PATHS OR CONDUCTORS NOT CONNECTED			OFF-DELAY TIMED CONTACT			LIGHT, INDICATING (PILOT, SIGNALLING, OR SWITCHBOARD)			TRANSFORMER, CURRENT			VARISTOR			CONDUCTOR, JUNCTION OF CONNECTED PATHS, CONDUCTORS OR WIRES			SWITCH, FLOW - ACTUATED, CLOSES ON INCREASE IN FLOW			LIGHT, INDICATING PUSH-TO-TEST			HALL EFFECT CURRENT SENSOR			THERMOCOUPLE			CONDUCTOR, SHIELDED SINGLE OR MULTICONDUCTOR			SWITCH, LIQUID LEVEL ACTUATED (FLDAT) CLOSING ON RISING LEVEL			LIGHT, INDICATING (LED TYPE)			GROUND			HEATSINK			CONDUCTORS, TWISTED			SWITCH, PRESSURE OR VACUUM OPERATED CLOSING ON RISING PRESSURE			METER (* : METER'S FUNCTION)			FERRITE						WIRE GAUGE MARKER			SWITCH, TEMPERATURE ACTUATED, OPENING ON RISING TEMPERATURE			RECEPTACLE			GROUNDING BALL						CONNECTOR, SEPARABLE OR JACKS ENGAGED			SWITCH, SELECTOR (MULTIPOSITION) WITH CONTACT CLOSED INDICATOR X - INDICATES CONTACTS CLOSE			PLC OUTPUT									TERMINAL			SWITCH, SELECTOR (MULTIPOSITION) WITH PUSHBUTTON TYPE CONTACT MECHANISM X - INDICATES CONTACTS CLOSED			GENERATOR			POWER ELECTRONIC DEVICES						TERMINAL (ROCKWELL AUTOMATION USE ONLY)			PLC INPUT						DIODE, SEMICONDUCTOR						TERMINAL BLOCKS									RECTIFIER SILICON CONTROLLED						— BARRIER									SYMMETRICAL GATE-COMMUTATED THYRISTOR AND GATE DRIVER BOARD						E - END BARRIER									RECTIFIER, FULL WAVE BRIDGE						WIRED TO / FROM DESTINATION (ARROW DIRECTION RELATIVE TO FLOW OF DRAWING ONLY)														
WIRING			SWITCHES AND INPUT DEVICES			OUTPUT DEVICES			RESISTORS, CAPS, WINDINGS AND GROUND			PROTECTION																																																																																																																																																																																																																																																																																																	
CONDUCTOR, OR CONDUCTIVE PATH			SWITCH, SINGLE THROW			COIL, OPERATING			CAPACITOR			CIRCUIT BREAKER, CONTROL/POWER																																																																																																																																																																																																																																																																																																	
CONDUCTOR, ASSOCIATED OR FUTURE (NOT SUPPLIED BY ROCKWELL AUTOMATION)			SWITCH, TOGGLE (MAINTAINED POSITION) TRANSFER, SINGLE POLE			COIL, BLOWOUT			RESISTOR, GENERAL			FUSE, CONTROL/POWER																																																																																																																																																																																																																																																																																																	
TEMPORARY WIRING			PUSHBUTTON			FAN (3Ø INDUCTION MOTOR)			RESISTOR, ADJUSTABLE (POTENTIOMETER)			OVERLOAD RELAY, THERMAL																																																																																																																																																																																																																																																																																																	
COPPER BUS BAR			SWITCH, MUSHROOM HEAD, (MAINTAINED)			FAN (1Ø INDUCTION MOTOR)			REACTOR, SATURABLE CORE			SURGE SUPPRESSOR																																																																																																																																																																																																																																																																																																	
MECHANICALLY CONNECTED			CONTACT			INDUCTION MACHINE			WINDING			SWITCH, DISCONNECT (FUSED)																																																																																																																																																																																																																																																																																																	
CABLE, MULTICONDUCTOR			ON-DELAY TIMED CONTACT			INDUCTION MACHINE (SYNCHRONOUS)			TRANSFORMER, WITH MAGNETIC CORE			SWITCH, DISCONNECT (NON FUSED)																																																																																																																																																																																																																																																																																																	
CONDUCTOR, CROSSING OF PATHS OR CONDUCTORS NOT CONNECTED			OFF-DELAY TIMED CONTACT			LIGHT, INDICATING (PILOT, SIGNALLING, OR SWITCHBOARD)			TRANSFORMER, CURRENT			VARISTOR																																																																																																																																																																																																																																																																																																	
CONDUCTOR, JUNCTION OF CONNECTED PATHS, CONDUCTORS OR WIRES			SWITCH, FLOW - ACTUATED, CLOSES ON INCREASE IN FLOW			LIGHT, INDICATING PUSH-TO-TEST			HALL EFFECT CURRENT SENSOR			THERMOCOUPLE																																																																																																																																																																																																																																																																																																	
CONDUCTOR, SHIELDED SINGLE OR MULTICONDUCTOR			SWITCH, LIQUID LEVEL ACTUATED (FLDAT) CLOSING ON RISING LEVEL			LIGHT, INDICATING (LED TYPE)			GROUND			HEATSINK																																																																																																																																																																																																																																																																																																	
CONDUCTORS, TWISTED			SWITCH, PRESSURE OR VACUUM OPERATED CLOSING ON RISING PRESSURE			METER (* : METER'S FUNCTION)			FERRITE																																																																																																																																																																																																																																																																																																				
WIRE GAUGE MARKER			SWITCH, TEMPERATURE ACTUATED, OPENING ON RISING TEMPERATURE			RECEPTACLE			GROUNDING BALL																																																																																																																																																																																																																																																																																																				
CONNECTOR, SEPARABLE OR JACKS ENGAGED			SWITCH, SELECTOR (MULTIPOSITION) WITH CONTACT CLOSED INDICATOR X - INDICATES CONTACTS CLOSE			PLC OUTPUT																																																																																																																																																																																																																																																																																																							
TERMINAL			SWITCH, SELECTOR (MULTIPOSITION) WITH PUSHBUTTON TYPE CONTACT MECHANISM X - INDICATES CONTACTS CLOSED			GENERATOR			POWER ELECTRONIC DEVICES																																																																																																																																																																																																																																																																																																				
TERMINAL (ROCKWELL AUTOMATION USE ONLY)			PLC INPUT						DIODE, SEMICONDUCTOR																																																																																																																																																																																																																																																																																																				
TERMINAL BLOCKS									RECTIFIER SILICON CONTROLLED																																																																																																																																																																																																																																																																																																				
— BARRIER									SYMMETRICAL GATE-COMMUTATED THYRISTOR AND GATE DRIVER BOARD																																																																																																																																																																																																																																																																																																				
E - END BARRIER									RECTIFIER, FULL WAVE BRIDGE																																																																																																																																																																																																																																																																																																				
WIRED TO / FROM DESTINATION (ARROW DIRECTION RELATIVE TO FLOW OF DRAWING ONLY)																																																																																																																																																																																																																																																																																																													
THIS DRAWING IS THE PROPERTY OF ROCKWELL AUTOMATION, INC. OR ITS SUBSIDIARIES AND MAY NOT BE COPIED, USED OR DISCLOSED FOR ANY PURPOSE EXCEPT AS AUTHORIZED IN WRITING BY ROCKWELL AUTOMATION, INC.	CERTIFIED	DATE	REV	REVISION		INT	DATE	CUSTOMER	CARRIER CORPORATION			ORDER NO.	DESCRIPTION SYMBOL TABLE	BULLETIN	7000A		DWG. NO.	SHEET 16																																																																																																																																																																																																																																																																																											
				PRELIMINARY		JF	2013-06-28	DISTRIBUTOR				SIZE		XXXA	REV				1	CARRIER-003-13E	OF 16																																																																																																																																																																																																																																																																																								
	DRAWN	J.FILIPOVIC	DATE					PROJECT																																																																																																																																																																																																																																																																																																					